

JOB No. 15-0824

# DOCUMENT REGISTER & TRANSMITTAL

PROJECT : KARIJINI SKINCARE RETAIL STORE

TENANCY : 1-1253 ZONE 12, GROUND LEVEL

WESTFEILD CAROUSEL CANNINGTON WA 6107



THE RECIPIENT MUST READ THE DISCLAIMER ON THE LAST PAGE

<b>DATE OF ISSUE</b>	DAY		15											
	MONTH		08											
	YEAR		24											

DOCUMENT	DESCRIPTION	REVISION											
		A1	A										
A00	Cover Sheet	A1	A										
A01	Ground Floor Plan, Partition and Flooring & Finishes Plan	A1	A										
A02	Reflected Ceiling & Lighting Plan	A1	A										
A03	Feature Ceiling Plan	A1	A										
A04	Feature Ceiling Section	A1	A										
A05	External Elevations - Sheet One	A1	A										
A06	Internal Elevations - Sheet Two	A1	A										
A07	Internal Elevations - Sheet One	A1	A										
A08	Internal Elevations - Sheet Two	A1	A										
A09	Internal Elevations - Sheet Three	A1	A										
A10	Shop Front Details - Sheet Two	A1	A										
A11	Ceiling Details	A1	A										
A12	Joinery Details - Sheet One	A1	A										
A13	Joinery Details - Sheet Two	A1	A										
A14	Joinery Details - Sheet Three	A1	A										
A15	Joinery Details - Sheet Four	A1	A										
A16	Joinery Details - Sheet Five	A1	A										
A17	Joinery Details - Sheet Six	A1	A										
A18	Joinery Details - Sheet Seven	A1	A										
A19	Joinery Details - Sheet Eight	A1	A										
A20	Joinery Details - Sheet Nine	A1	A										
A21	Joinery Details - Sheet Ten	A1	A										
A22	Signage Details - Sheet One	A1	A										
A23	Signage Details - Sheet Two	A1	A										
	Section 1 - Finishes, Fittings & Furniture Schedule	A1	A										

DISCLAIMER FOR THE USE OF GAIA STUDIO  
DESIGN ELECTRONIC DRAWINGS AND FILES

DISTRIBUTION LIST	NUMBER OF COPIES												
KARIJINI SKINCARE		1											
SCENTRE GROUP		1											
BUILDING CONSULTANTS & ENGINEERS		1											
MODE: Hand Mail		M											
MEDIA: Electronical Print		E											
PURPOSE OF ISSUE		T											
A Approval	I Information/Comment	R As Requested	CO Co-ordination										
T Tender	CT Contract	C Construction											



DISCLAIMER THIS IMAGE IS A REPRESENTATIONAL DIGITAL VISUALISATION



Interiors  
Project Management

ABN 00 11 222 333  
44 Perth Street  
Perth WA 6000  
Australia  
+1234 5678

interiors@studiogaia.com.au  
www.studiogaia.com.au

## ISSUE FOR TENDER

**PROJECT :** KARIJINI SKINCARE RETAIL FITOUT


**ADDRESS :** TENANCY 1-1253 ZONE 12, GROUND LEVEL  
1382 ALBANY HWY, CANNINGTON WA 6107

**DATE :** AUGUST 2024


**REVISION :** A

## ID SHEET LIST


A00	COVER SHEET	A
A01	GROUND FLOOR PLAN, PARTITION AND FLOORING & FINISHES PLAN	A
A02	REFLECTED CEILING & LIGHTING PLAN	A
A03	FEATURE CEILING PLAN	A
A04	FEATURE CEILING SECTION	A
A05	EXTERNAL ELEVATIONS - SHEET ONE	A
A06	EXTERNAL ELEVATIONS - SHEET TWO	A
A07	INTERNAL ELEVATIONS - SHEET ONE	A
A08	INTERNAL ELEVATIONS - SHEET TWO	A
A09	INTERNAL ELEVATIONS - SHEET THREE	A
A10	SHOP FRONT DETAILS	A
A11	CEILING DETAILS	A
A12	JOINERY DETAILS - SHEET ONE	A
A13	JOINERY DETAILS - SHEET TWO	A
A14	JOINERY DETAILS - SHEET THREE	A
A15	JOINERY DETAILS - SHEET FOUR	A
A16	JOINERY DETAILS - SHEET FIVE	A
A17	JOINERY DETAILS - SHEET SIX	A
A18	JOINERY DETAILS - SHEET SEVEN	A
A19	JOINERY DETAILS - SHEET EIGHT	A
A20	JOINERY DETAILS - SHEET NINE	A
A21	JOINERY DETAILS - SHEET TEN	A
A22	SIGNAGE DETAILS - SHEET ONE	A
A23	SIGNAGE DETAILS - SHEET TWO	A

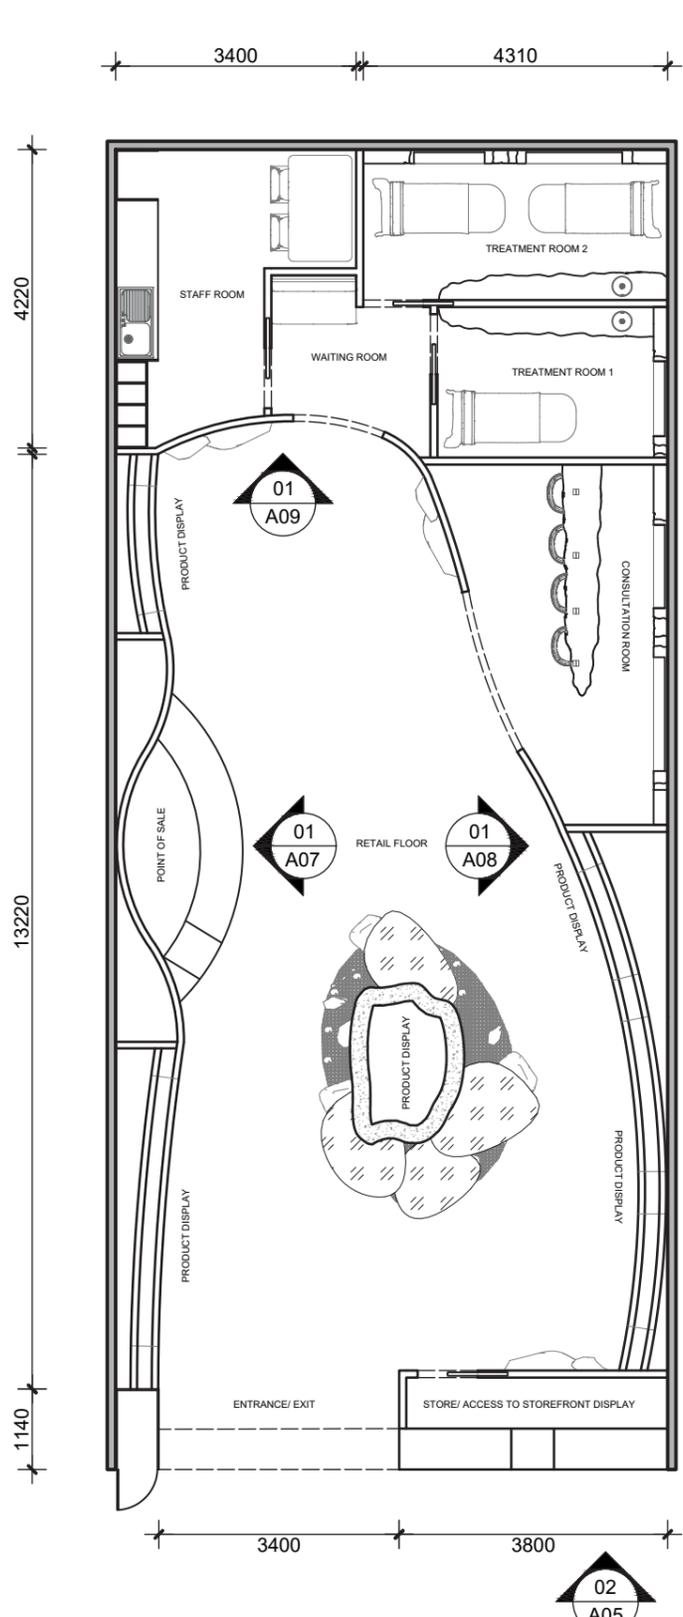

01 GROUND FLOOR PLAN  
A01 1:100

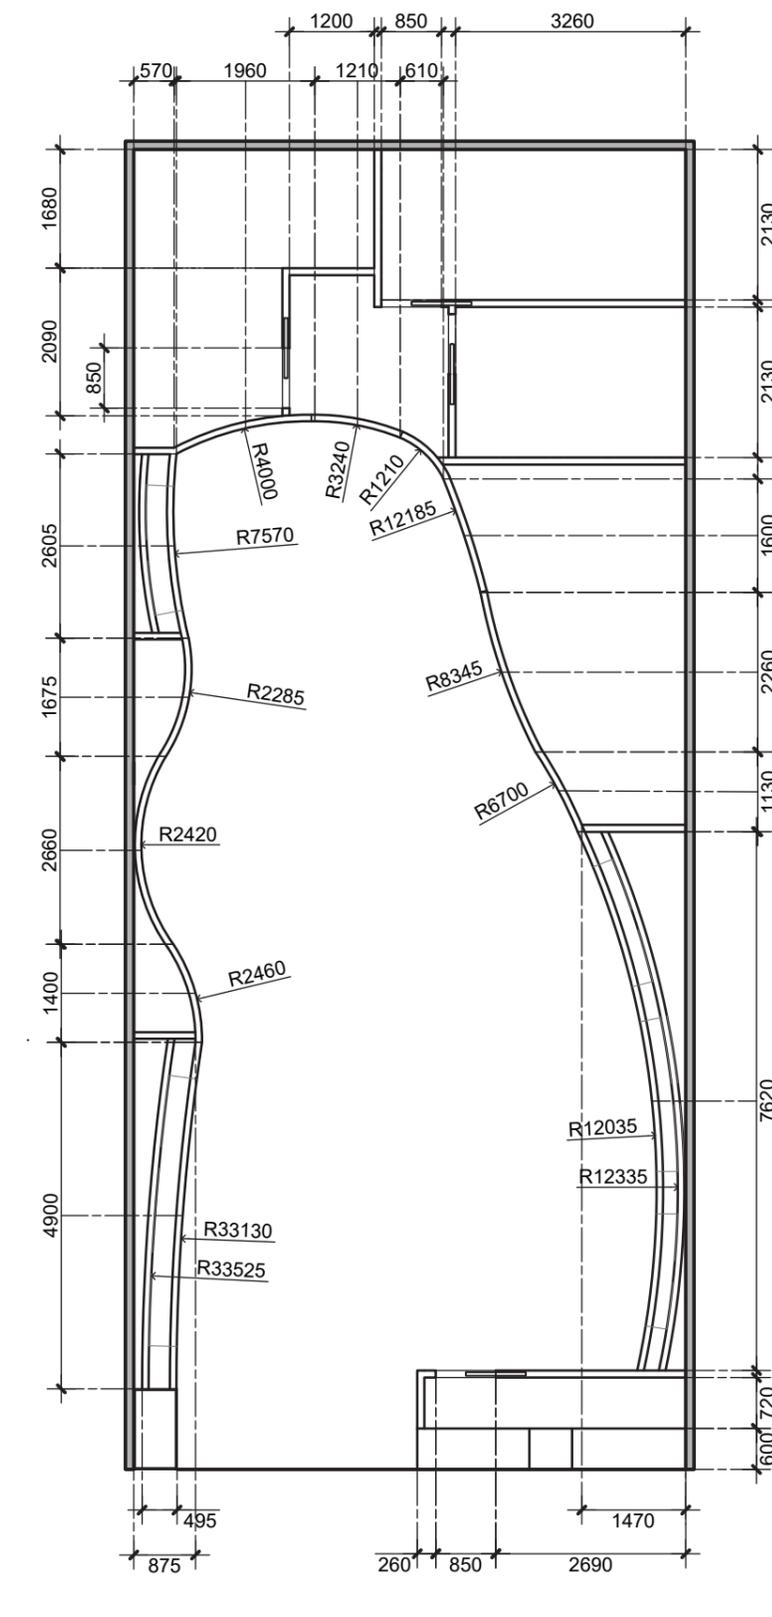

02 PARTITION PLAN  
A01 1:100

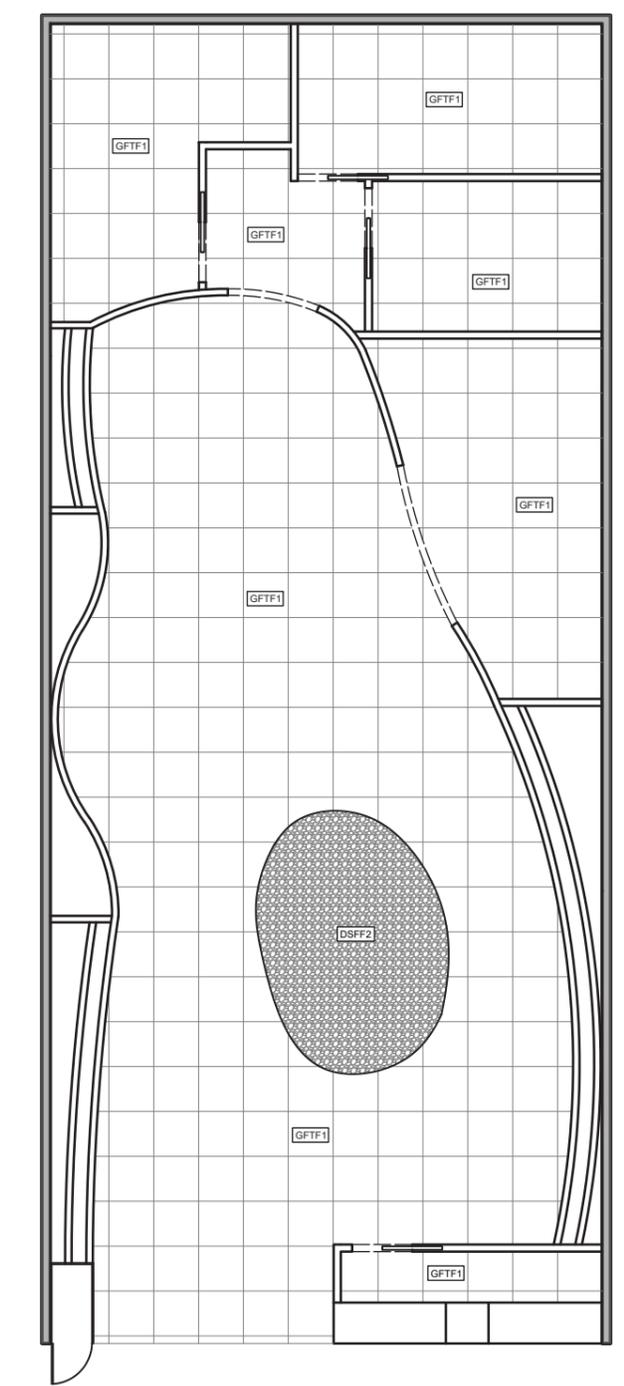

03 GROUND FLOORING & FINISHES PLAN  
A01 1:100



STUDIO GAIA  
1234 5678  
interiors@studiogaia.com.au  
www.studiogaia.com.au

NOTES:

CLIENT: LUCY MAJOR  
lucymajor@gmail.com  
0412 345 678

PROJECT: KARLINI SKINCARE RETAIL FIT OUT  
1-1253 ZONE 12, GROUND LEVEL  
WESTFIELD CAROUSEL, CANNINGTON WA 6107

STAGE: FOR TENDER

TITLE: GROUND FLOOR PLAN, PARTITION AND FLOORING & FINISHES

DRAWN BY: STUDIO GAIA


REVISION: NONE

DATE: 15-08-2024

SCALE: 1:100

**A01**



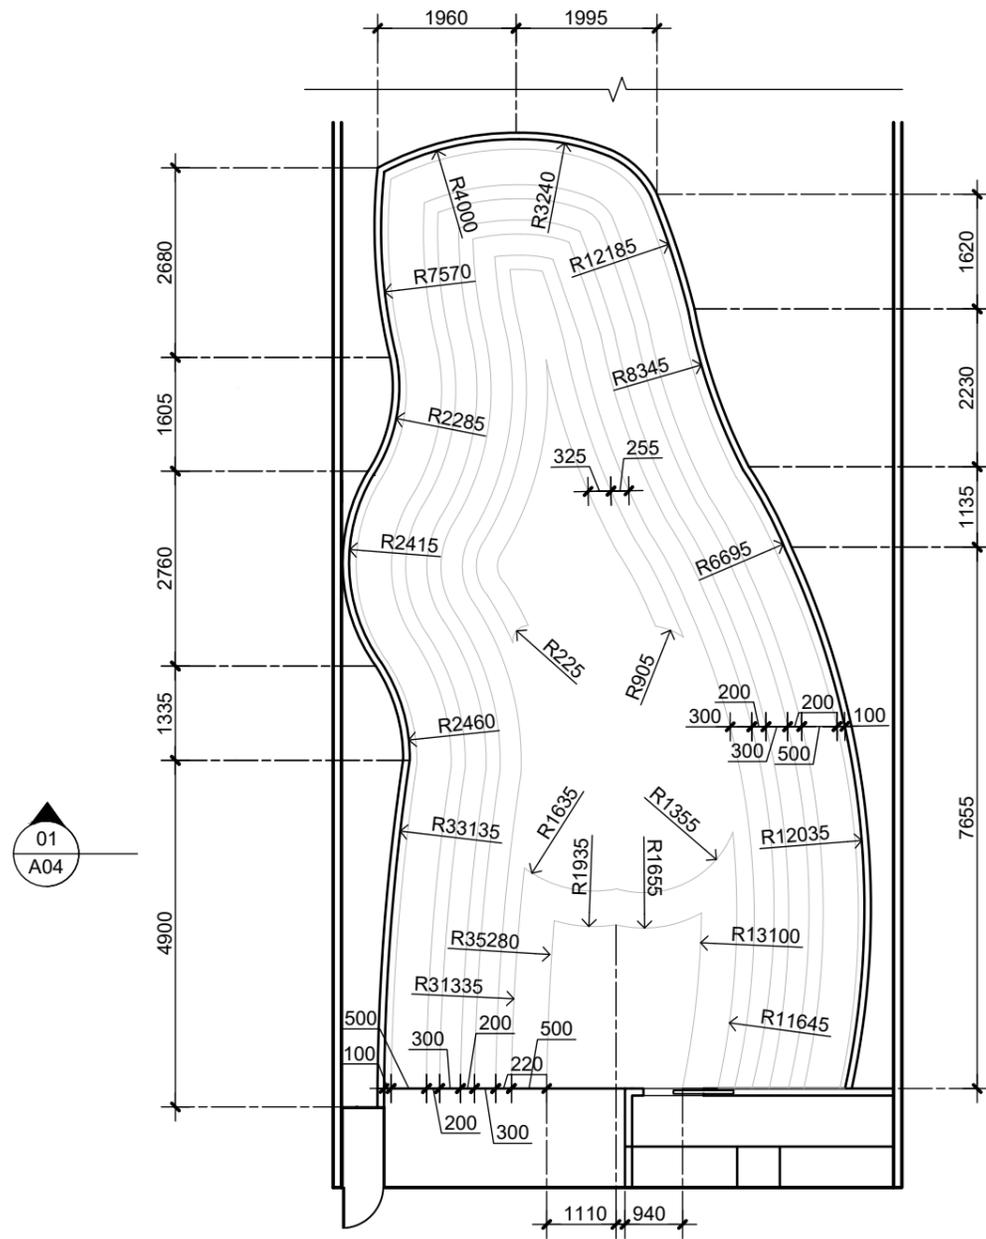

01 FEATURE CEILING PLAN  
A03 1:100



STUDIO GAIA  
1234 5678  
interiors@studiogaia.com.au  
www.studiogaia.com.au

NOTES:

CLIENT:

LUCY MAJOR  
lucymajor@email.com  
0412 345 678

STAGE:

FOR TENDER

DATE:15-08-2024

TITLE:

FEATURE CEILING PLAN

SCALE: 1:100

PROJECT:

KARLJINI SKINCARE RETAIL FIT OUT  
1-1253 ZONE 12, GROUND LEVEL  
WESTFIELD CAROUSEL, CANNINGTON WA 6107


DRAWN BY:

STUDIO GAIA

REVISION:


NONE

**A03**

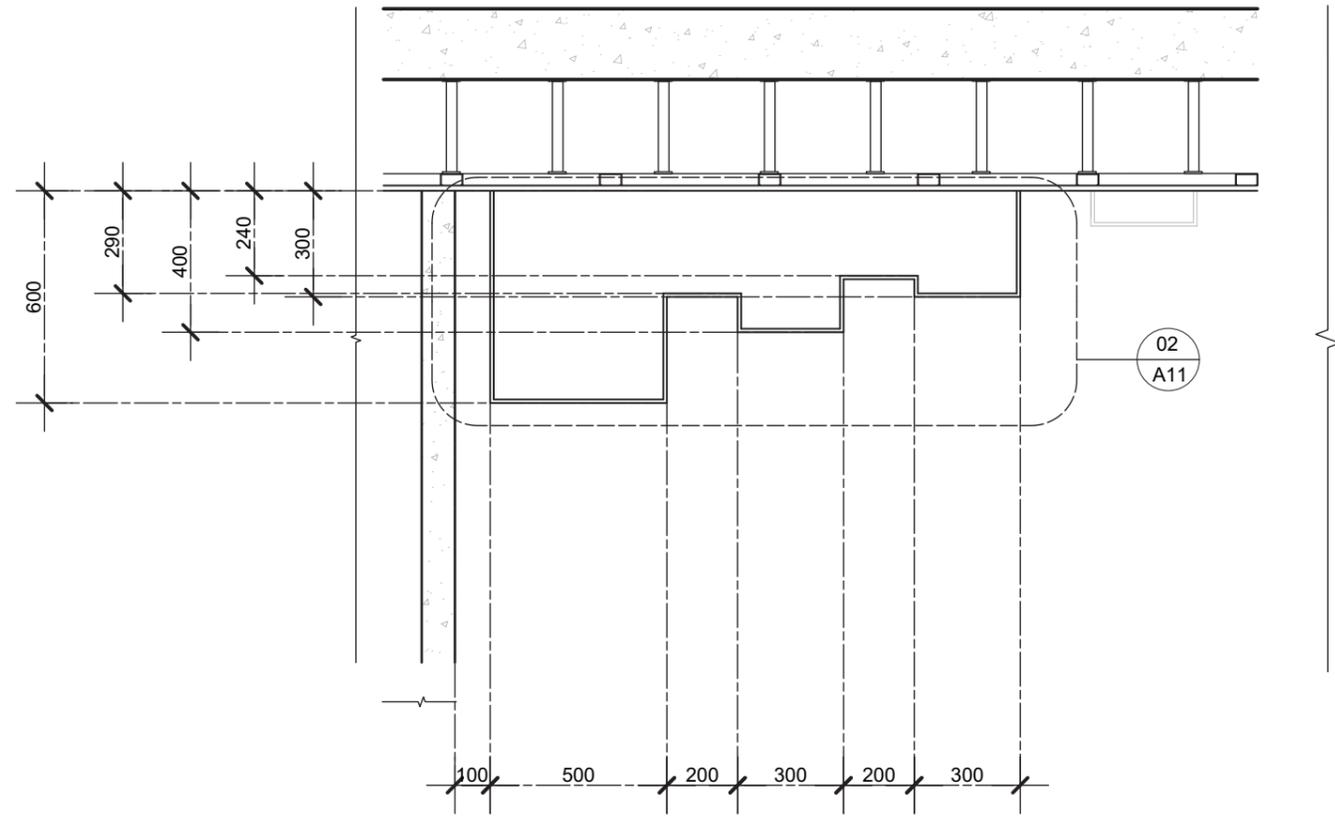


01 FEATURE CEILING SECTION  
A04 1:20

	<p>STUDIO GAIA 1234 5678 interiors@studiogaia.com.au www.studiogaia.com.au</p>	<p>NOTES:</p>	CLIENT:	LUCY MAJOR lucymajor@email.com 0412 345 678	STAGE:	FOR TENDER	DATE:15-08-2024
			PROJECT:	KARLJINI SKINCARE RETAIL FIT OUT 1-1253 ZONE 12, GROUND LEVEL WESTFIELD CAROUSEL, CANNINGTON WA 6107	TITLE:	FEATURE CEILING SECTION	SCALE: 1:20
					DRAWN BY:	STUDIO GAIA	<h1>A04</h1>
					REVISION:	NONE	

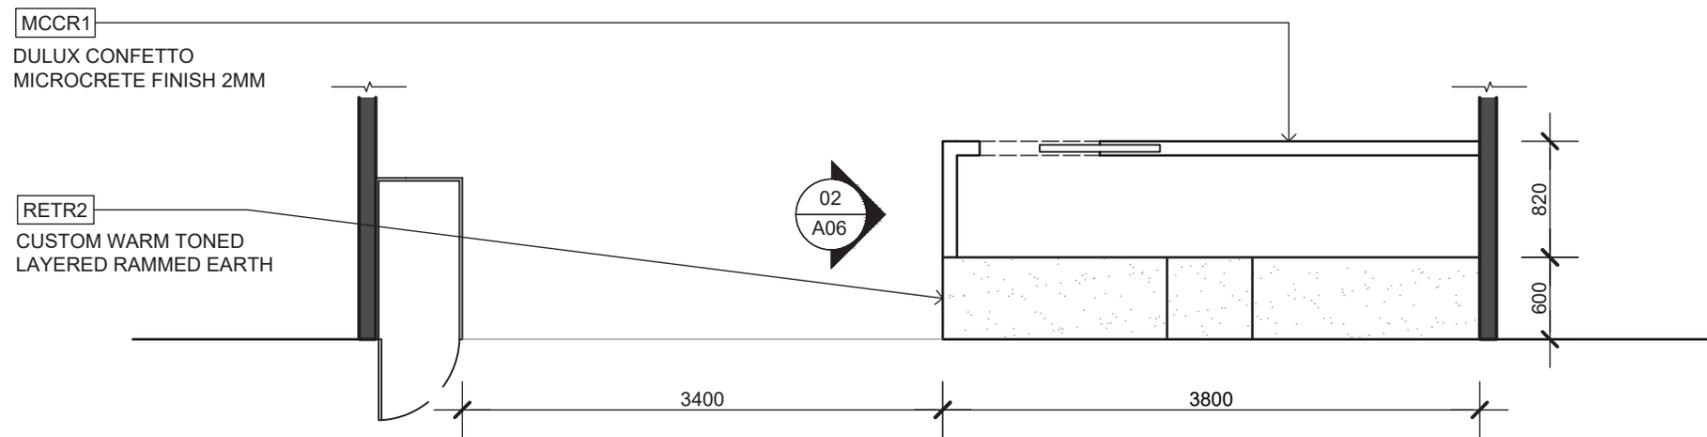

01 SHOP FRONT PLAN  
A05 1:50

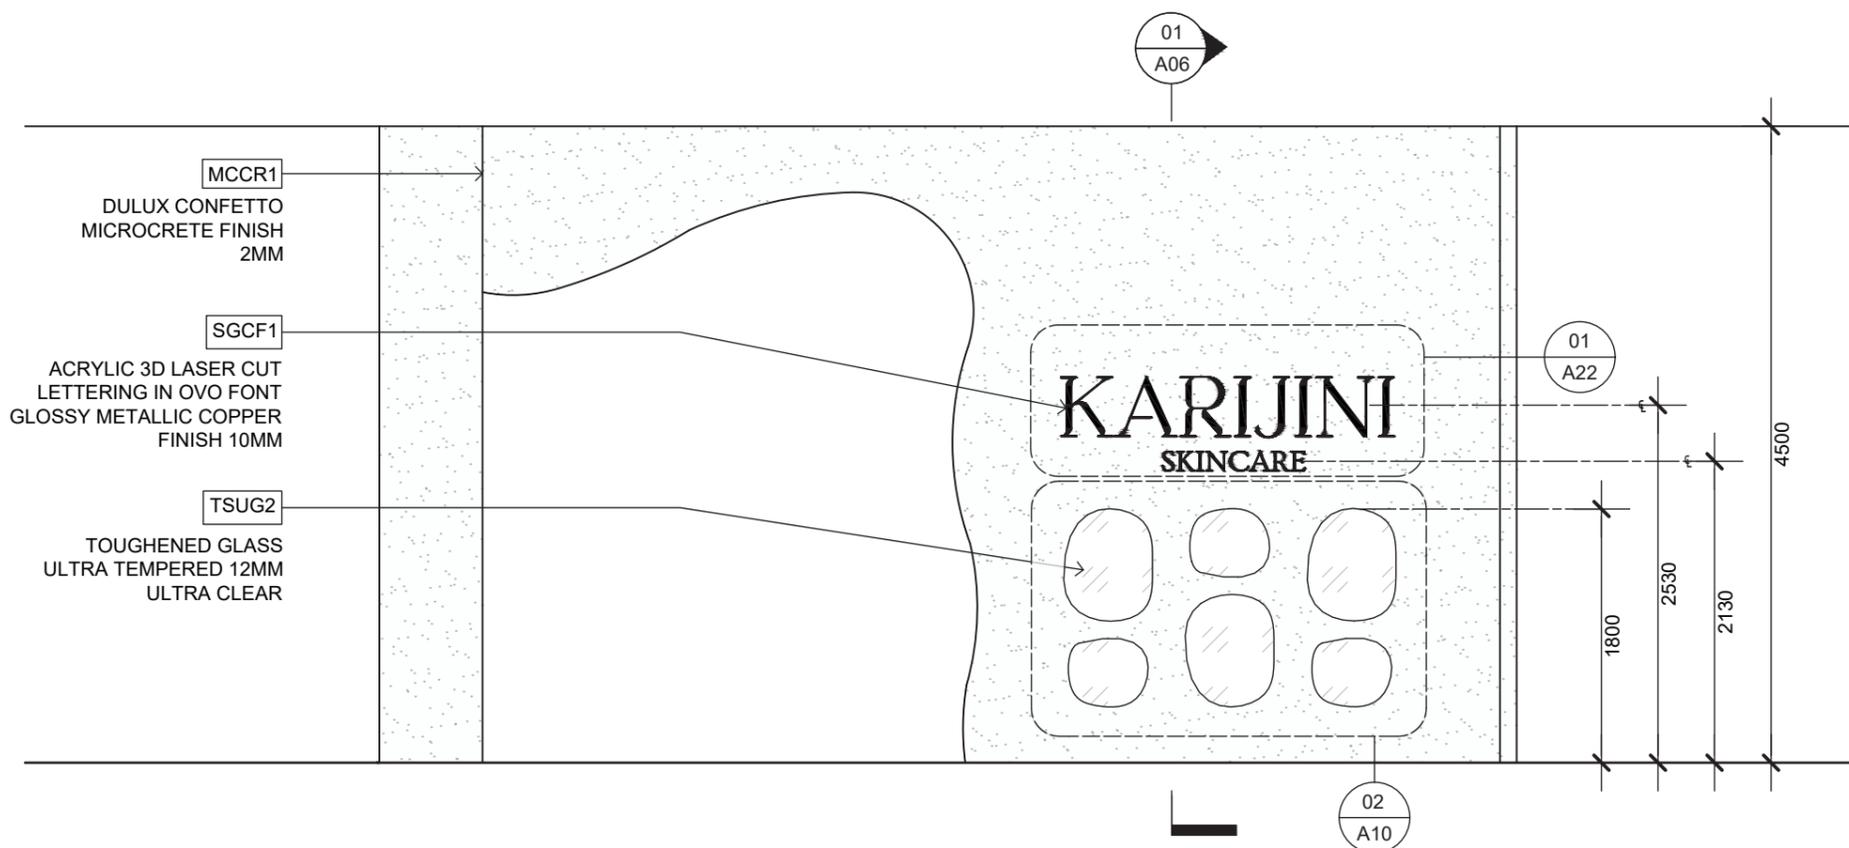

02 SHOP FRONT ELEVATION  
A05 1:50



STUDIO GAIA  
1234 5678  
interiors@studiogaia.com.au  
www.studiogaia.com.au

NOTES:

CLIENT:

LUCY MAJOR  
lucymajor@email.com  
0412 345 678

STAGE:

FOR TENDER

DATE:15-08-2024

TITLE:

EXTERNAL ELEVATIONS - SHEET ONE

SCALE: 1:50

PROJECT:

KARIJINI SKINCARE RETAIL FIT OUT  
1-1253 ZONE 12, GROUND LEVEL  
WESTFIELD CAROUSEL, CANNINGTON WA 6107


DRAWN BY:

STUDIO GAIA


REVISION:

NONE

**A05**

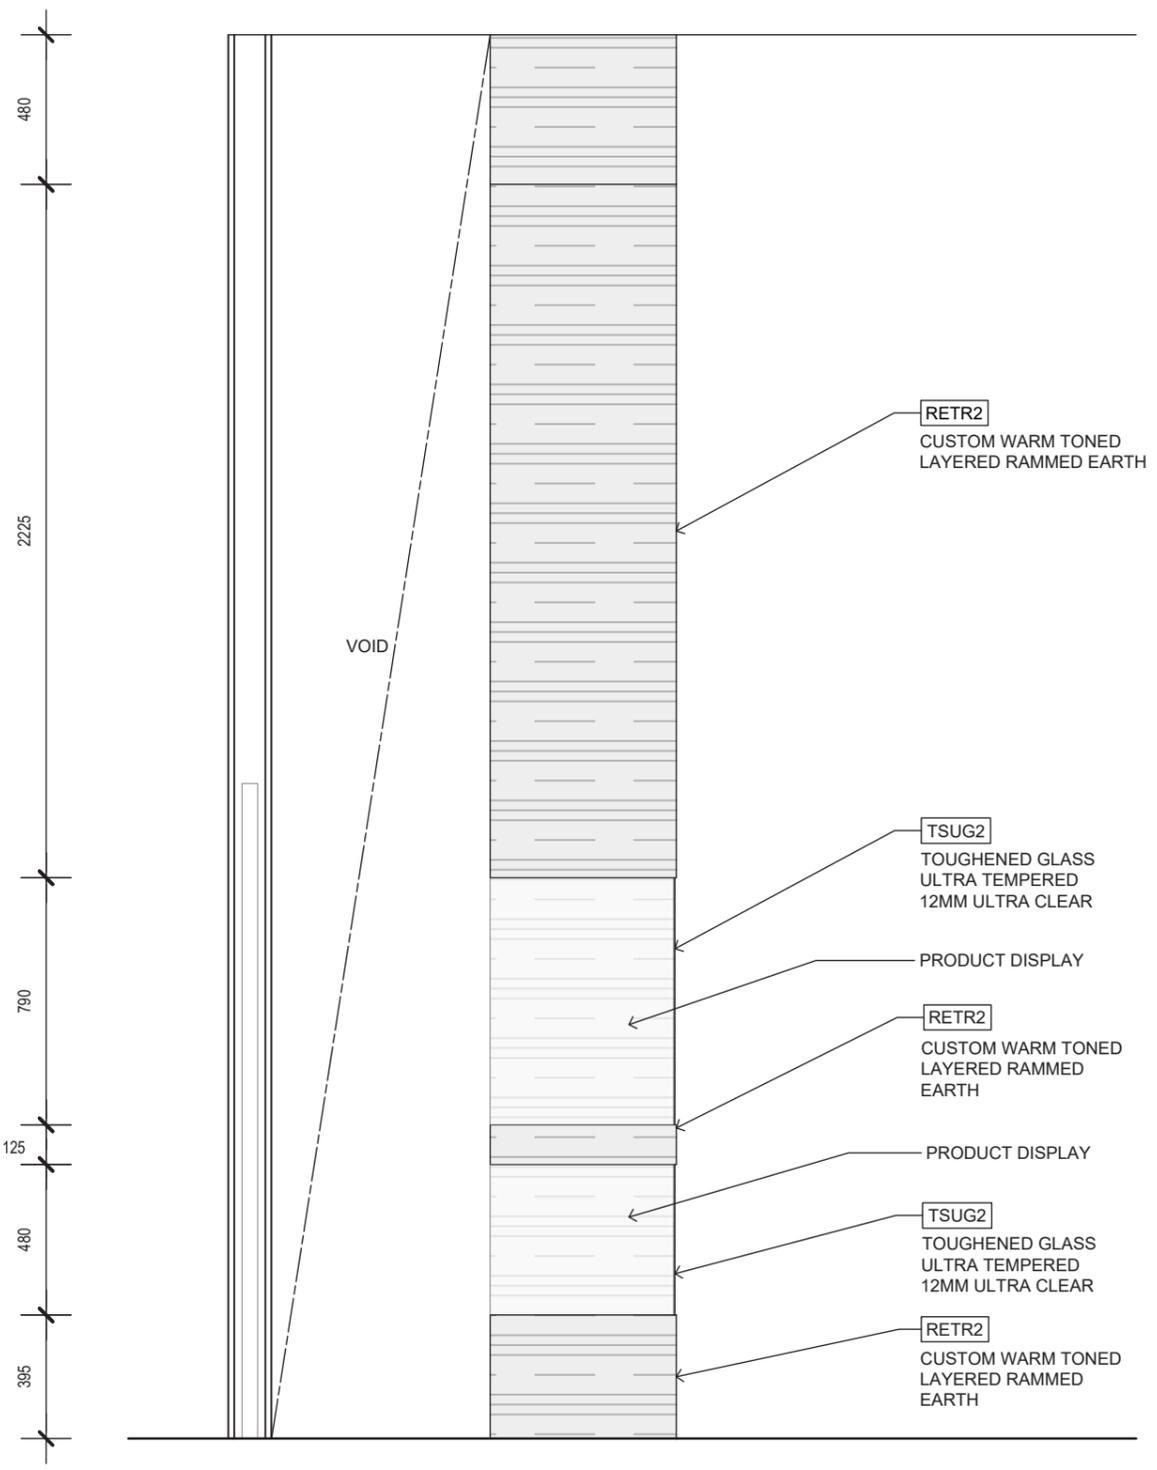

01 SHOP FRONT SECTION  
A06 1:20

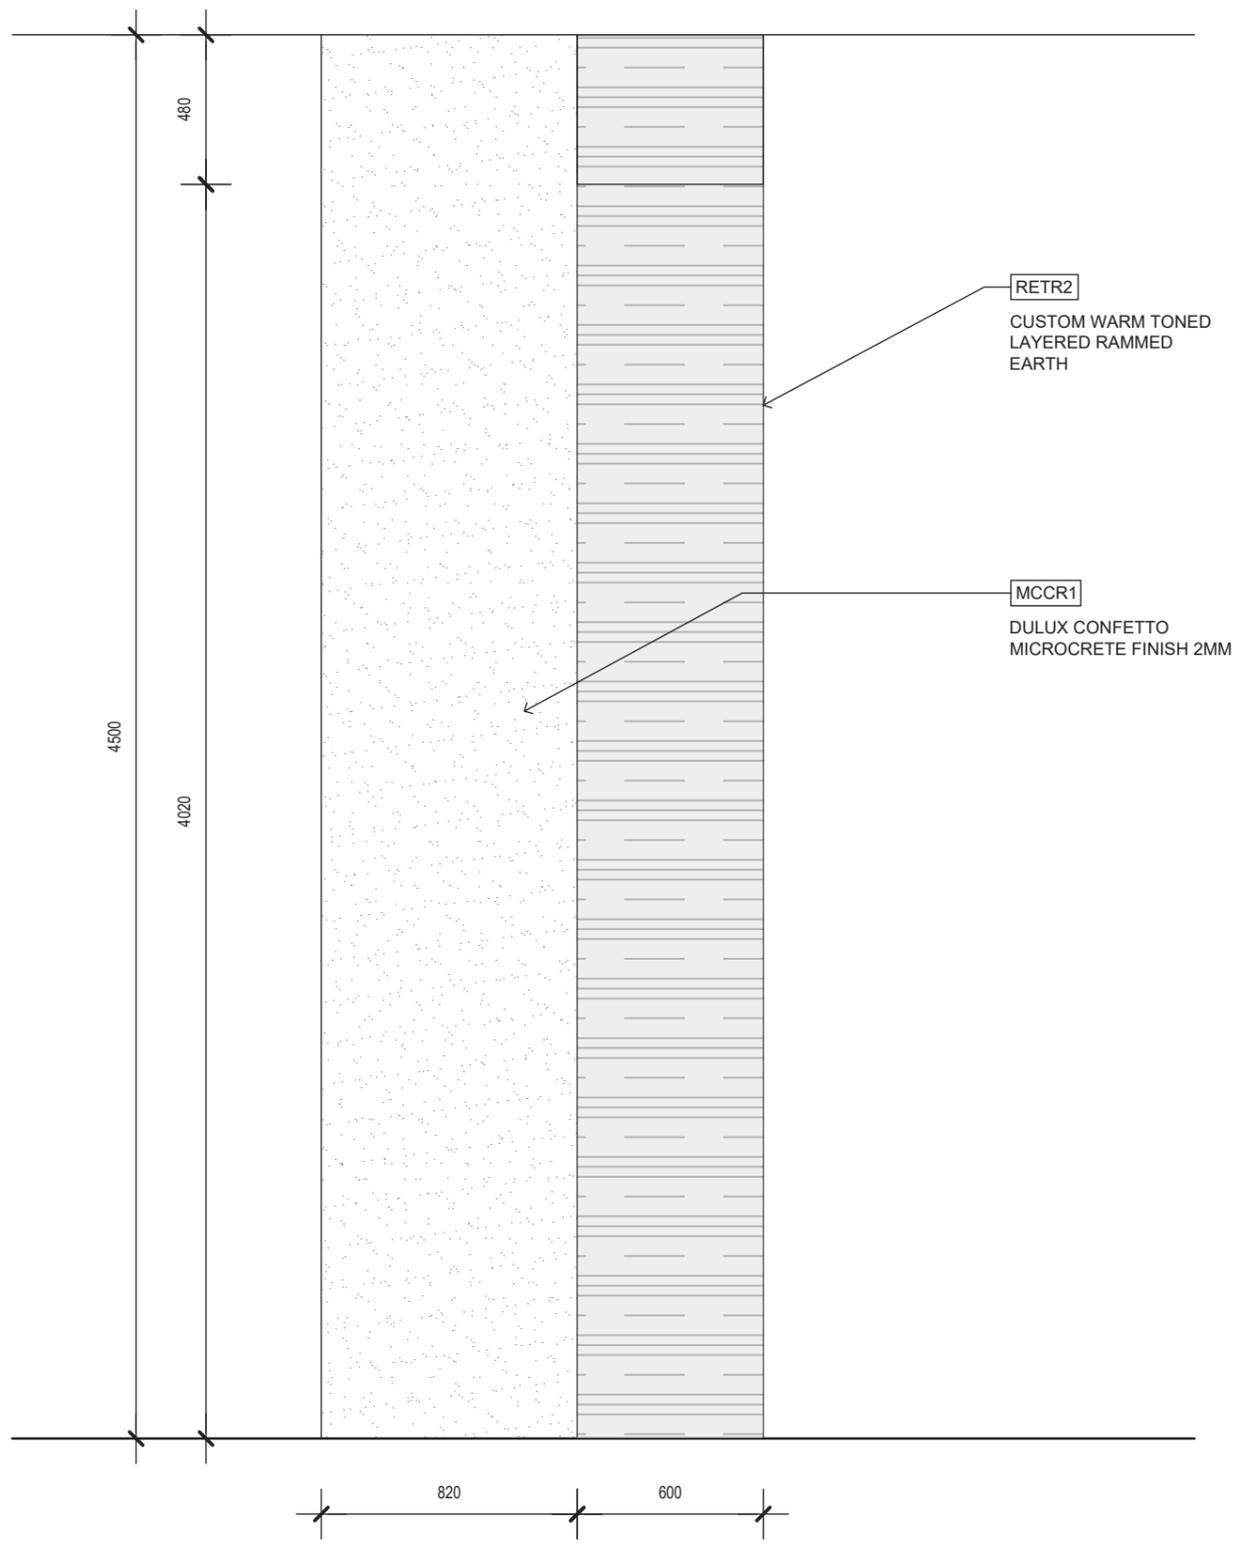

02 SHOP FRONT SHORT ELEVATION  
A06 1:20



STUDIO GAIA  
1234 5678  
interiors@studiogaia.com.au  
www.studiogaia.com.au

NOTES:

CLIENT:

LUCY MAJOR  
lucymajor@email.com  
0412 345 678

STAGE:

FOR TENDER

DATE:15-08-2024

TITLE:

EXTERNAL ELEVATIONS - SHEET TWO

SCALE: 1:20

PROJECT:

KARLJINI SKINCARE RETAIL FIT OUT  
1-1253 ZONE 12, GROUND LEVEL  
WESTFIELD CAROUSEL, CANNINGTON WA 6107


DRAWN BY:

STUDIO GAIA

REVISION:


NONE

**A06**

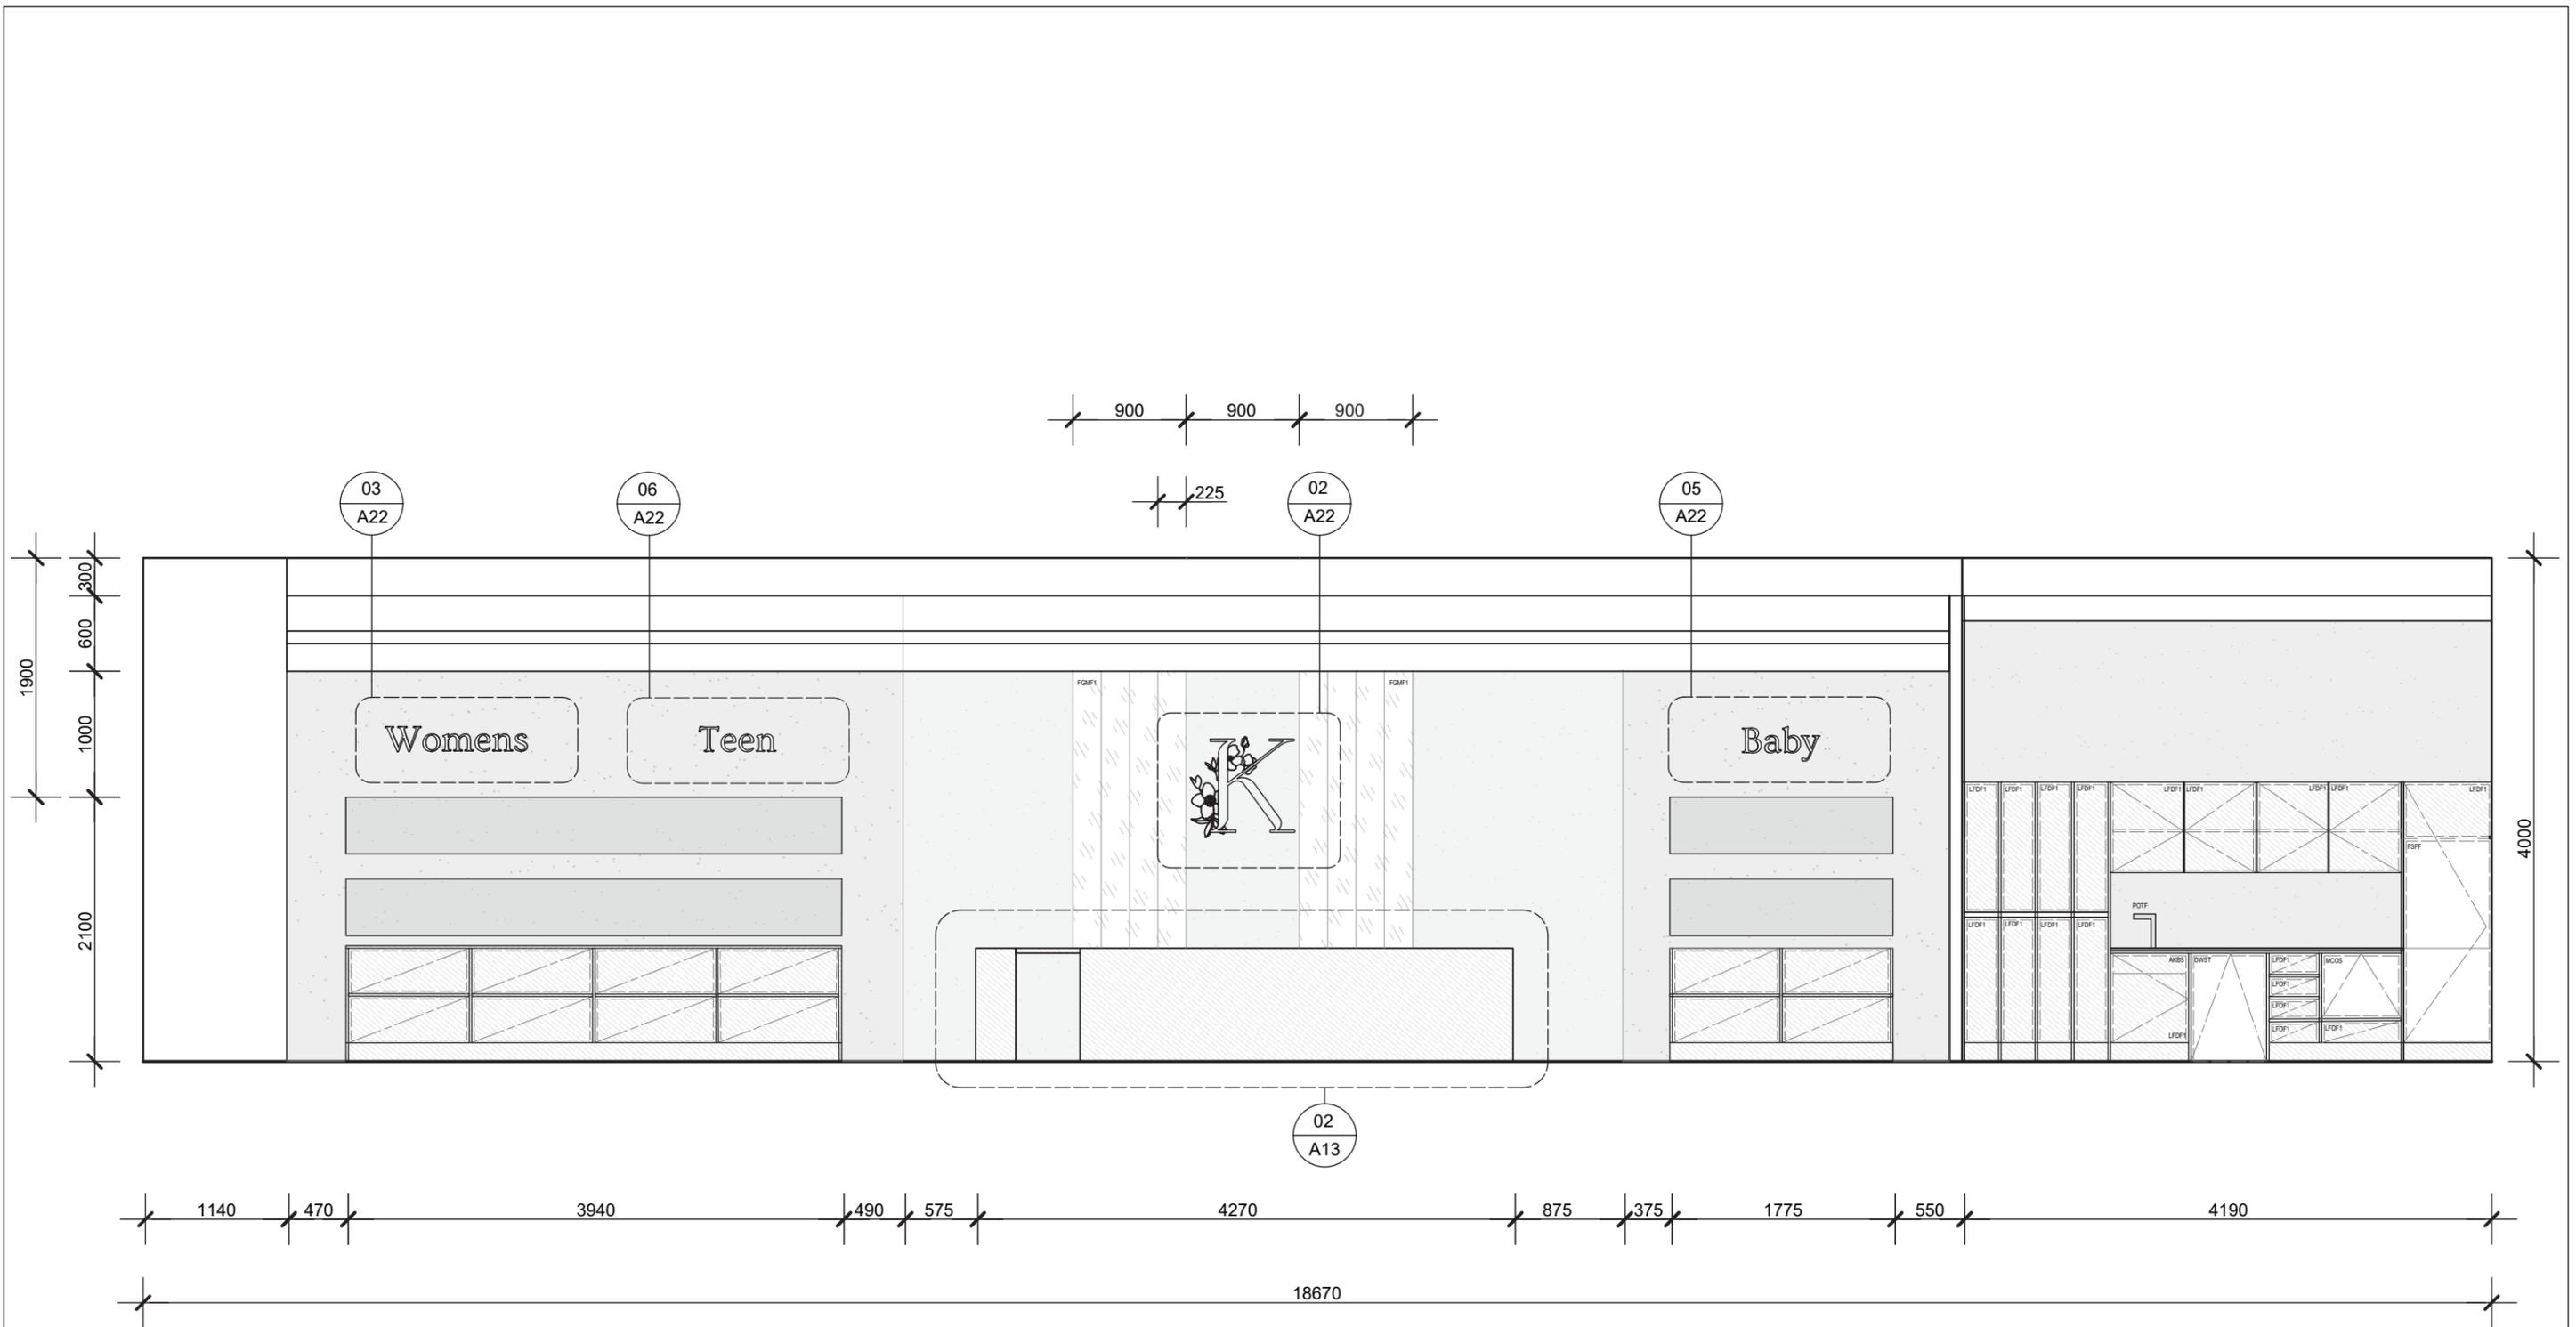


01 INTERNAL LONG ELEVATION 1  
A07 1:50

 <p>STUDIO GAIA 1234 5678 interiors@studiogaia.com.au www.studiogaia.com.au</p>	NOTES:	CLIENT:	LUCY MAJOR lucymajor@email.com 0412 345 678	STAGE:	FOR TENDER	DATE: 15-08-2024
		PROJECT:	KARLJINI SKINCARE RETAIL FIT OUT 1-1253 ZONE 12, GROUND LEVEL WESTFIELD CAROUSEL, CANNINGTON WA 6107	TITLE:	INTERNAL ELEVATIONS - SHEET ONE	SCALE: 1:50
				DRAWN BY:	STUDIO GAIA	<b>A07</b>
				REVISION:	NONE	

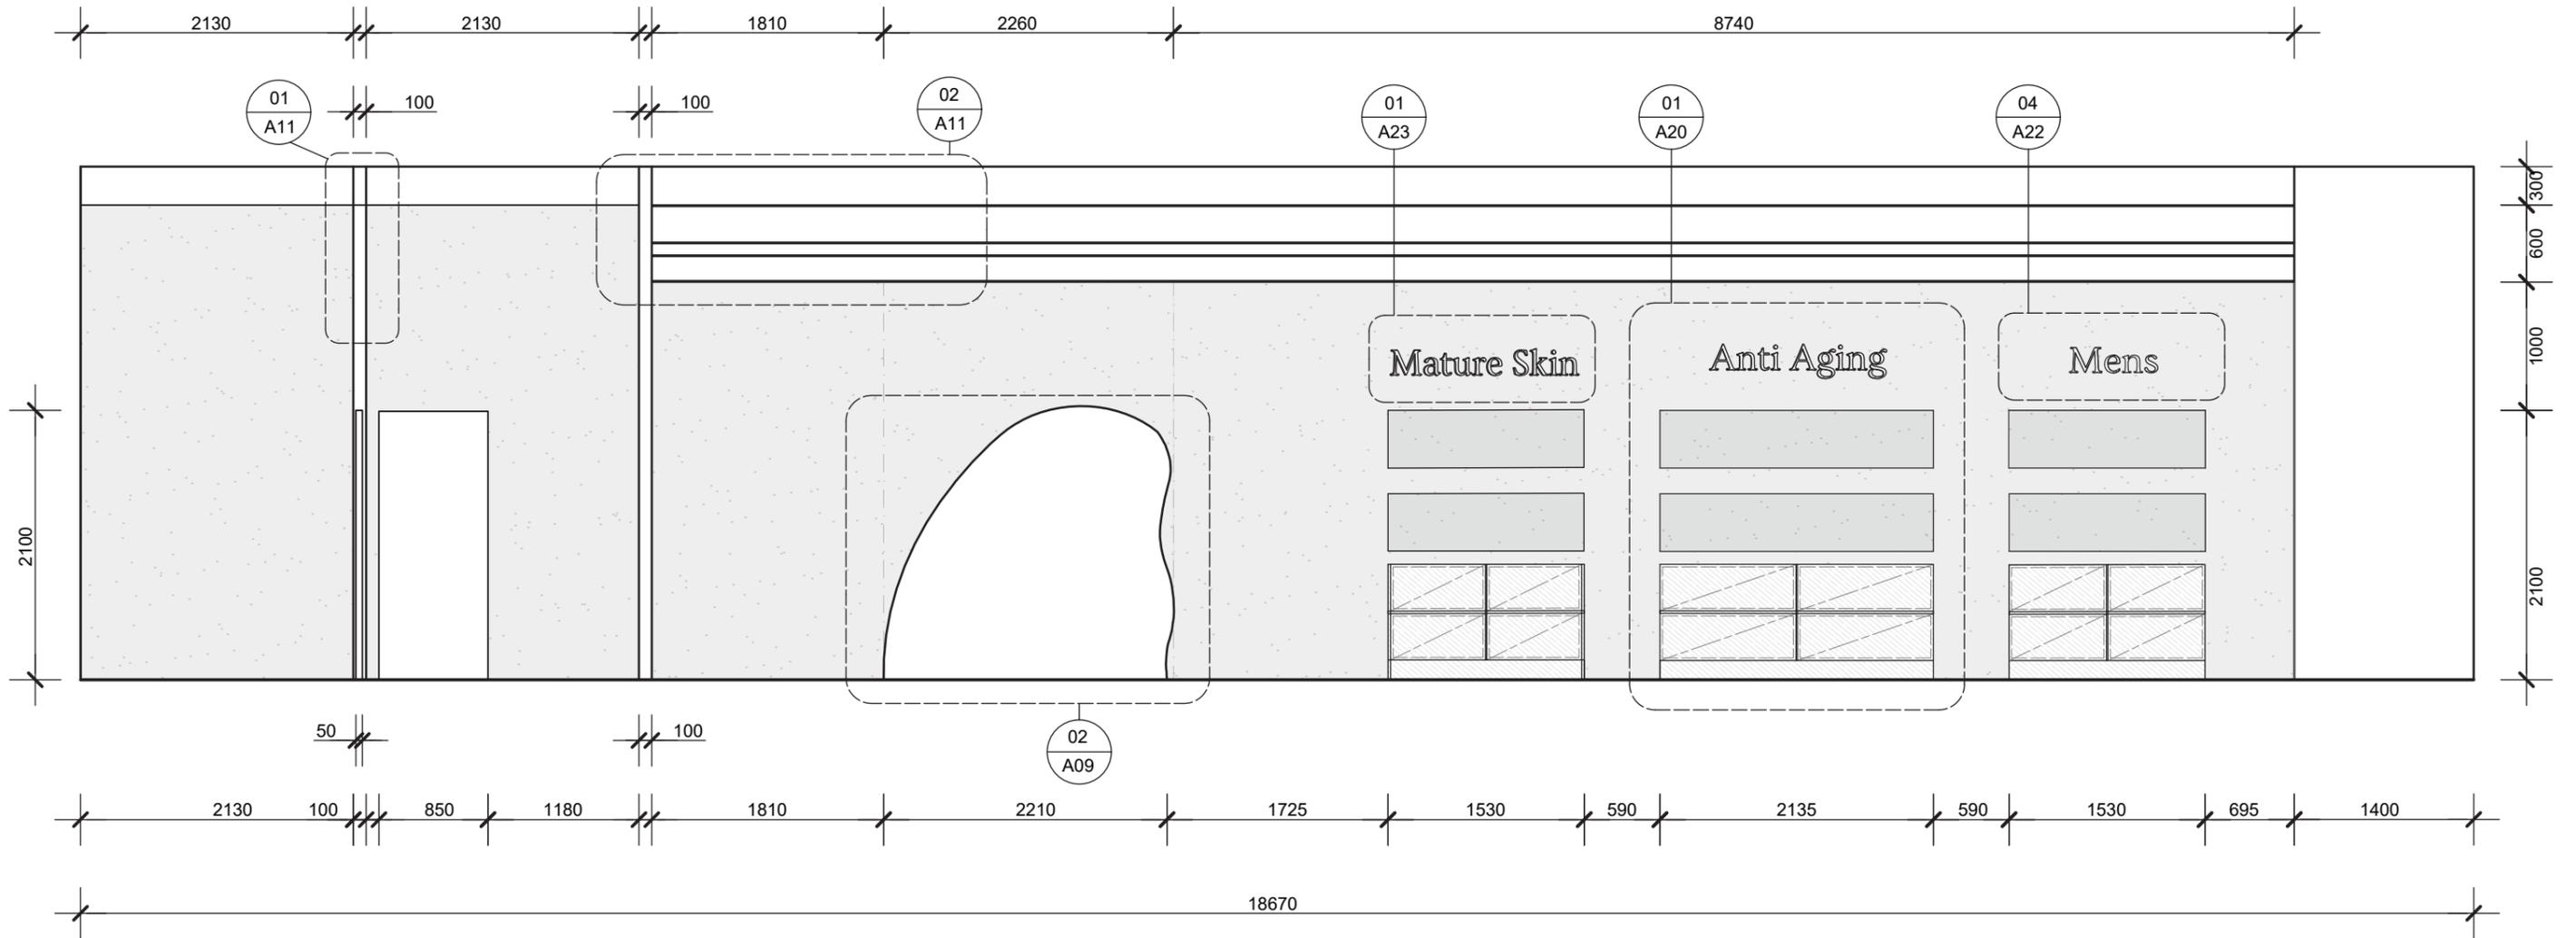


01 INTERNAL LONG ELEVATION 2  
A08 1:50

 <p>STUDIO GAIA 1234 5678 interiors@studiogaia.com.au www.studiogaia.com.au</p>	NOTES:	CLIENT:	LUCY MAJOR lucymajor@email.com 0412 345 678	STAGE:	FOR TENDER	DATE: 15-08-2024
		PROJECT:	KARLJINI SKINCARE RETAIL FIT OUT 1-1253 ZONE 12, GROUND LEVEL WESTFIELD CAROUSEL, CANNINGTON WA 6107	TITLE:	INTERNAL ELEVATIONS - SHEET TWO	SCALE: 1:50
				DRAWN BY:	STUDIO GAIA	<b>A08</b>
				REVISION:	NONE	

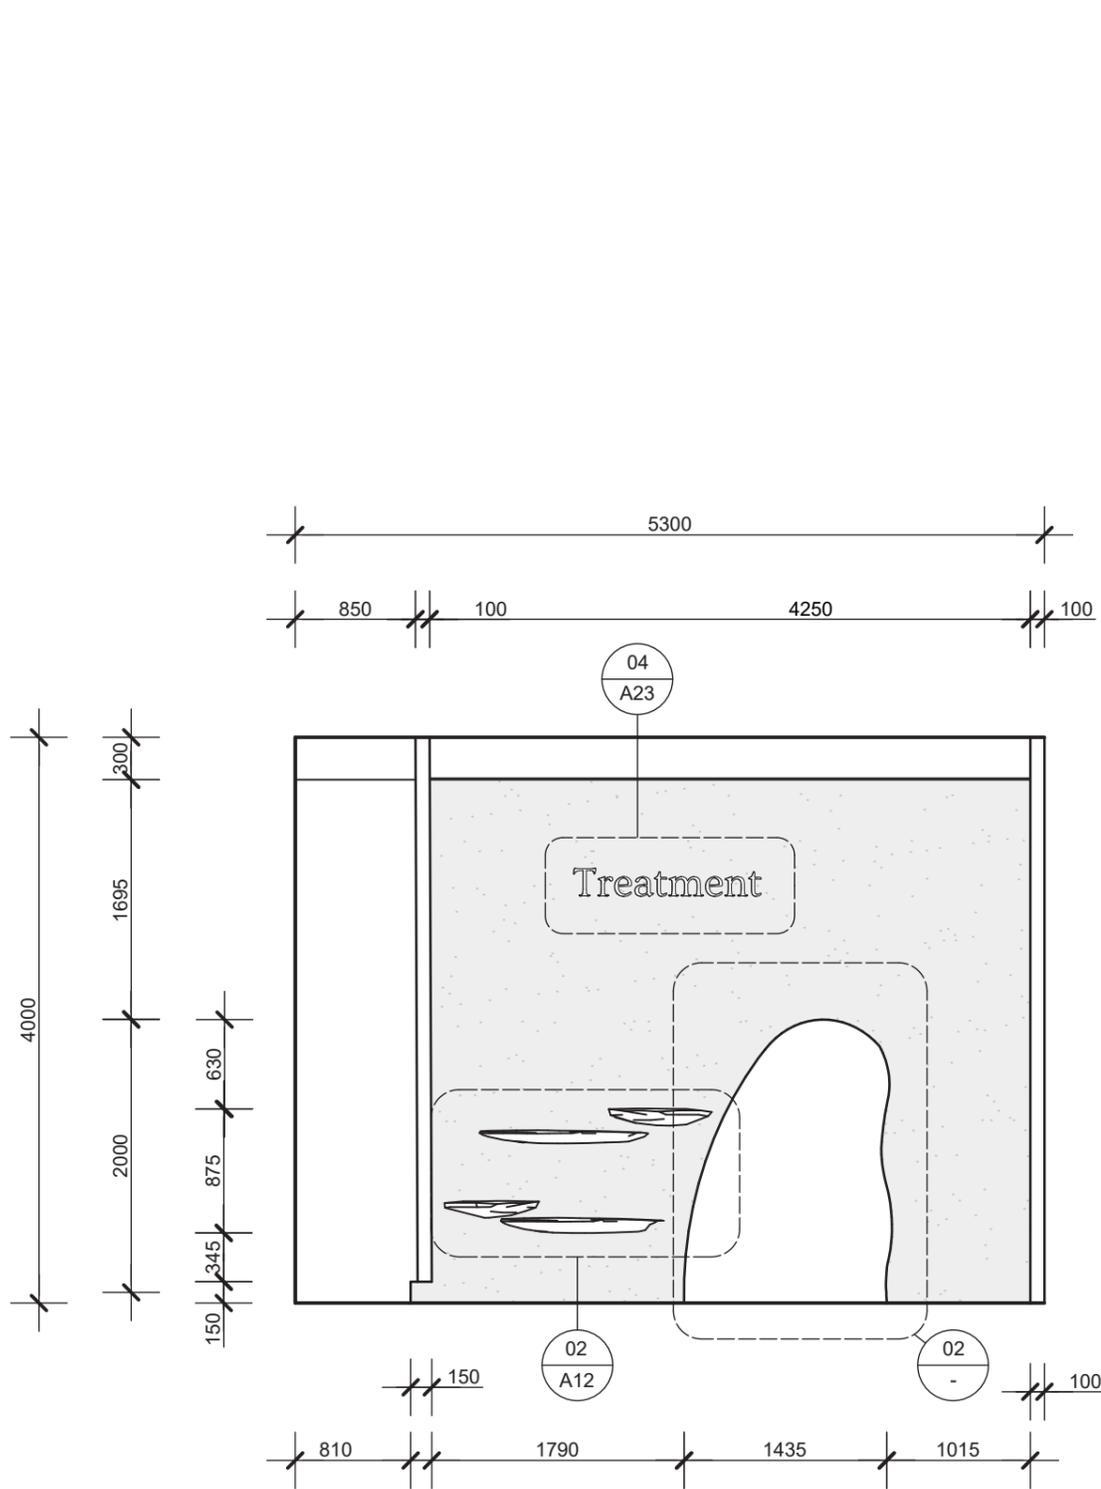

01 INTERNAL SHORT ELEVATION  
A09 1:50

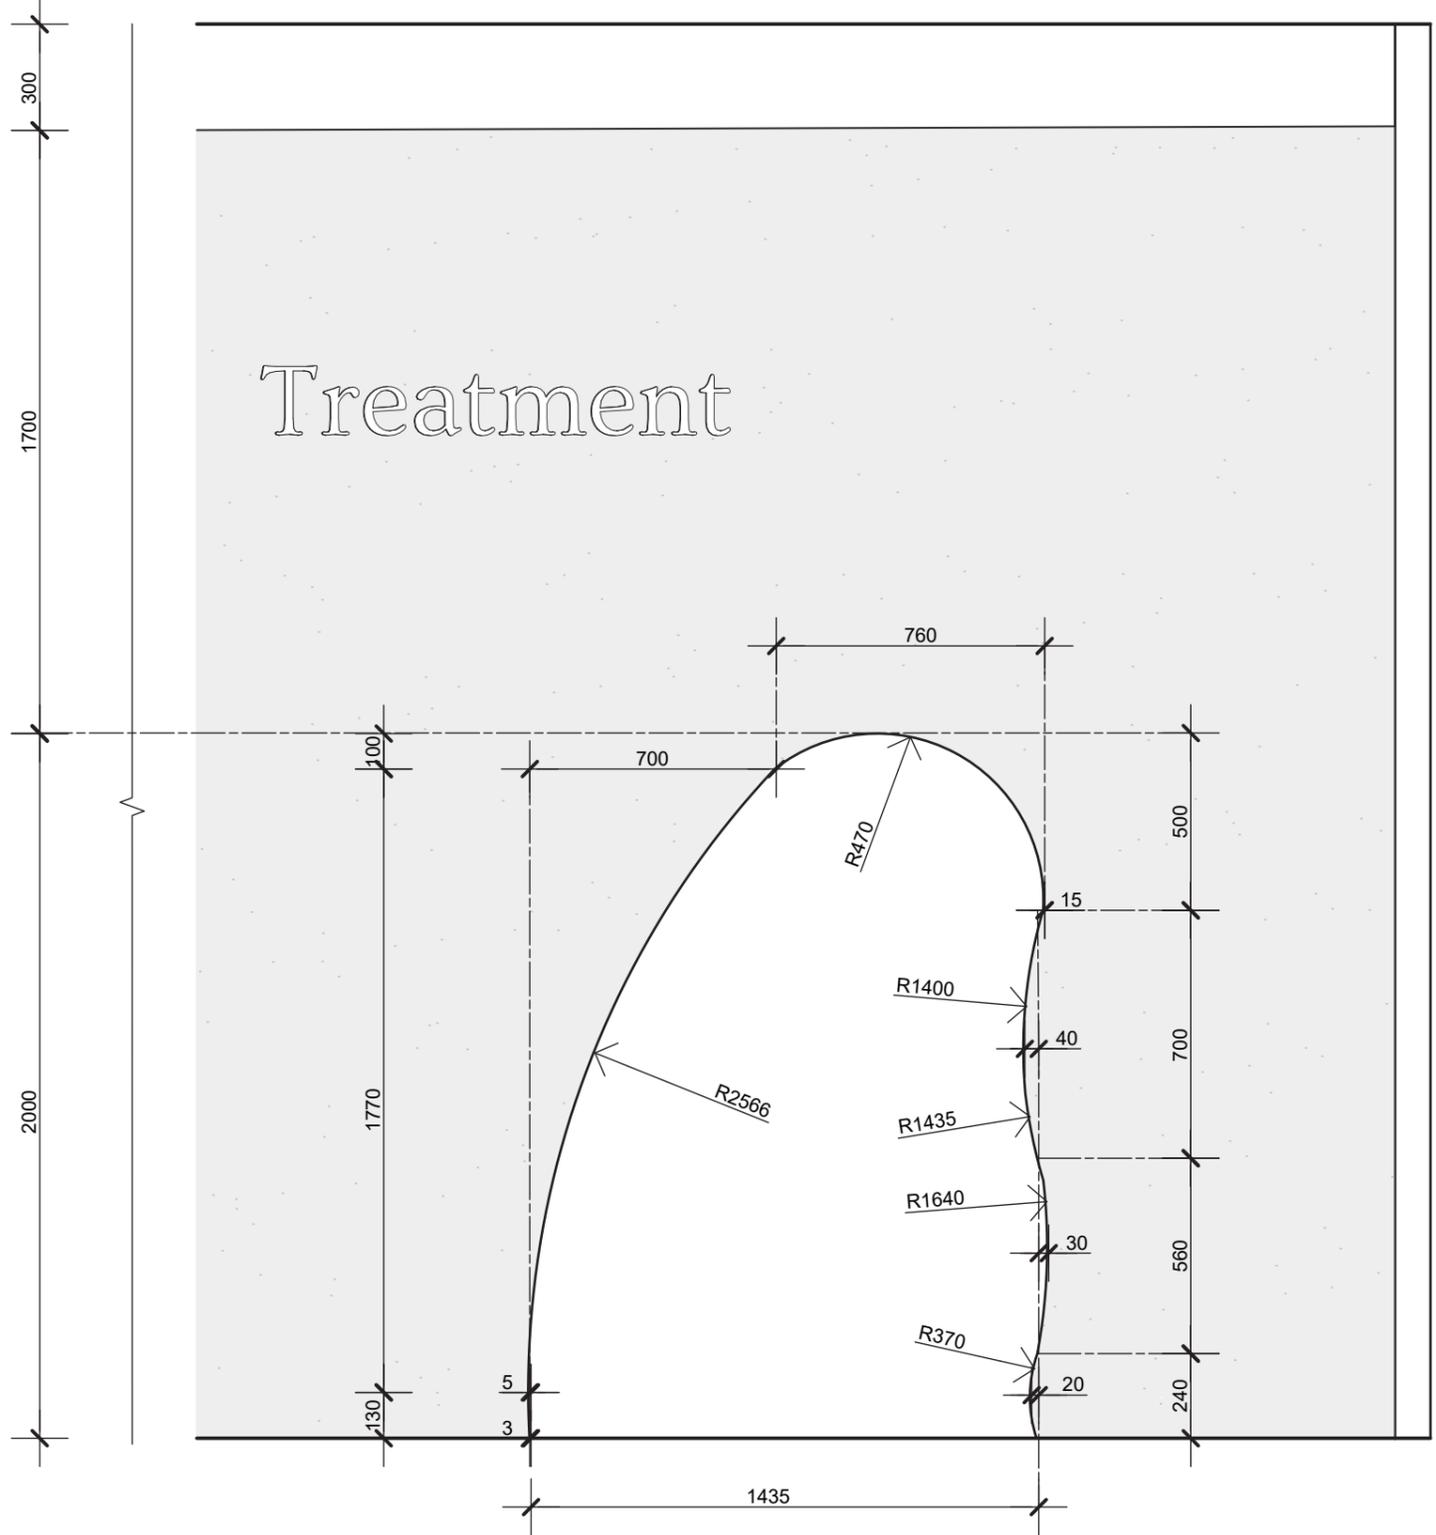

02 CURVED DOORWAY SETOUT  
A09 1:20



STUDIO GAIA  
1234 5678  
interiors@studiogaia.com.au  
www.studiogaia.com.au

NOTES:

CLIENT:

LUCY MAJOR  
lucymajor@email.com  
0412 345 678

STAGE:

FOR TENDER

DATE:15-08-2024

TITLE:

INTERNAL ELEVATIONS - SHEET THREE

VARIOUS SCALES

PROJECT:

KARLINI SKINCARE RETAIL FIT OUT  
1-1253 ZONE 12, GROUND LEVEL  
WESTFIELD CAROUSEL, CANNINGTON WA 6107


DRAWN BY:

STUDIO GAIA


REVISION:

NONE

A09

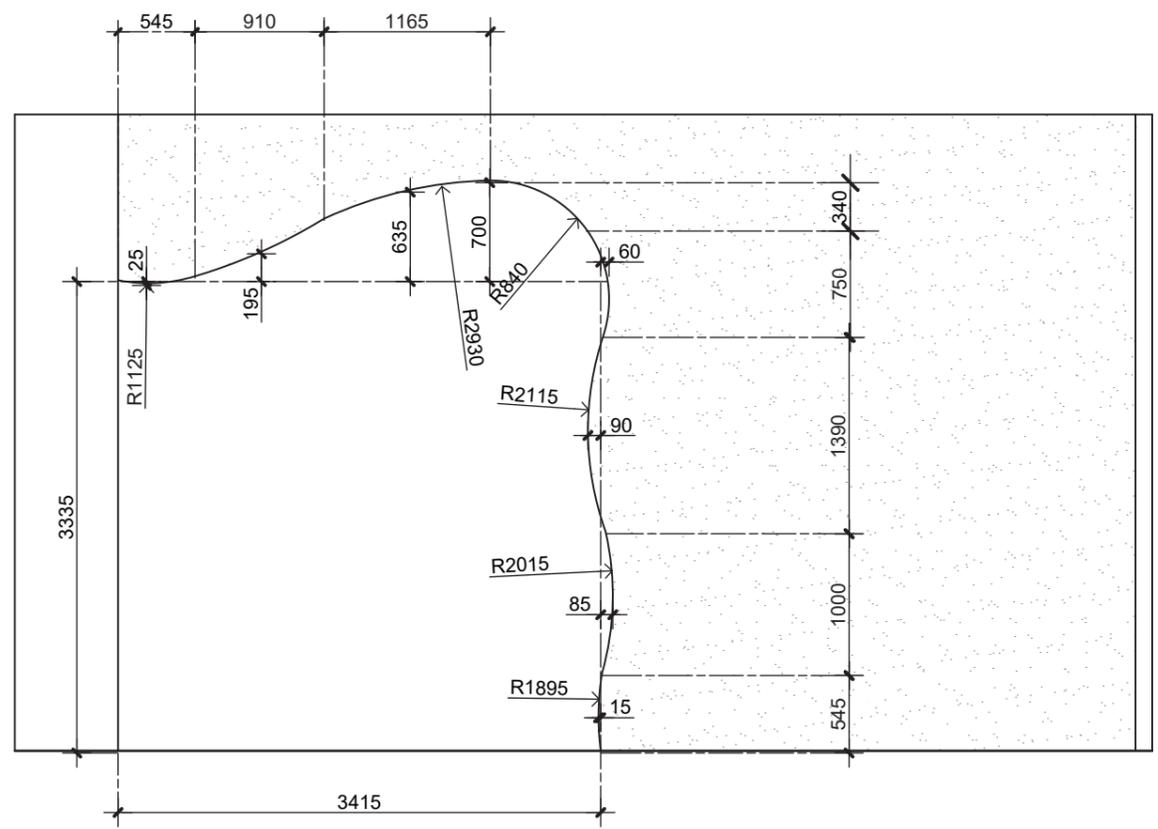

01 SHOP FRONT CURVES SETOUT  
A10 1:50

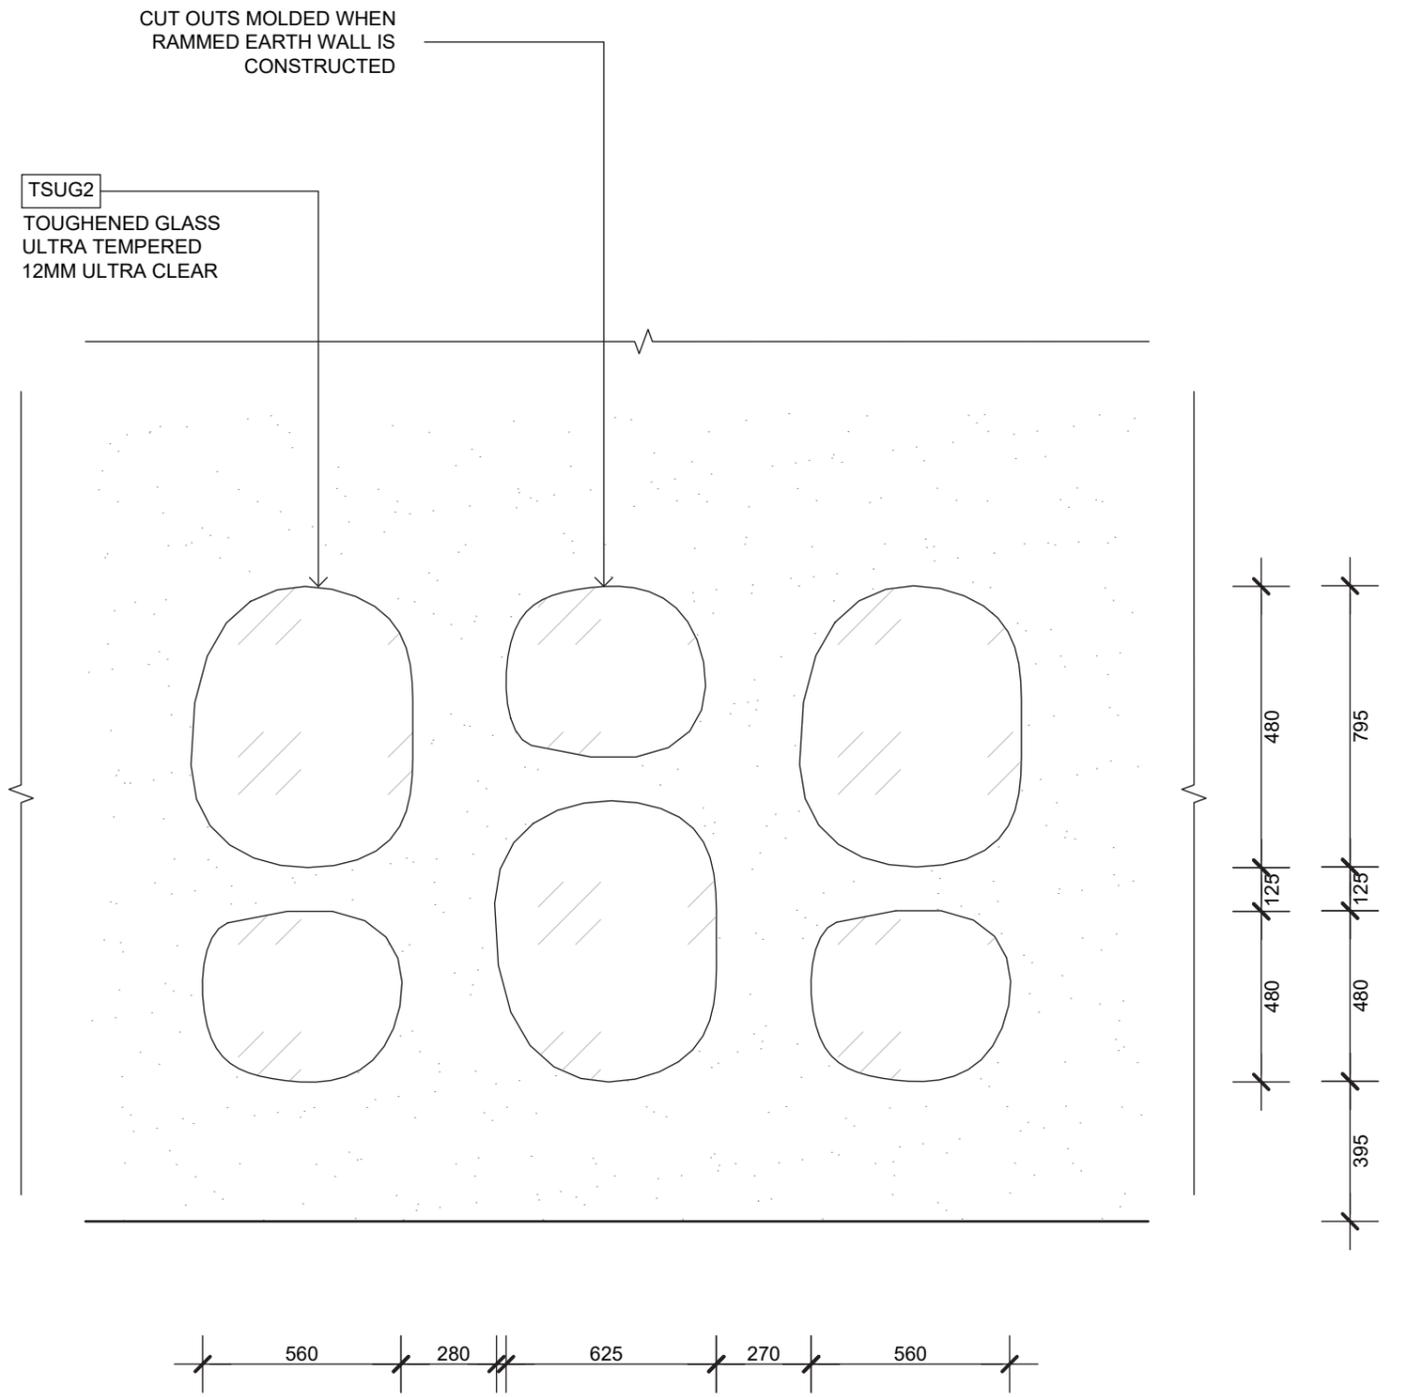

02 SHOP FRONT SHORT ELEVATION  
A10 1:20



STUDIO GAIA  
1234 5678  
interiors@studiogaia.com.au  
www.studiogaia.com.au

NOTES:

CLIENT:

LUCY MAJOR  
lucymajor@email.com  
0412 345 678

STAGE:

FOR TENDER

DATE: 15-08-2024

TITLE:

SHOP FRONT DETAILS

VARIOUS SCALES

PROJECT:

KARLJINI SKINCARE RETAIL FIT OUT  
1-1253 ZONE 12, GROUND LEVEL  
WESTFIELD CAROUSEL, CANNINGTON WA 6107


DRAWN BY:

STUDIO GAIA


REVISION:

NONE

**A10**

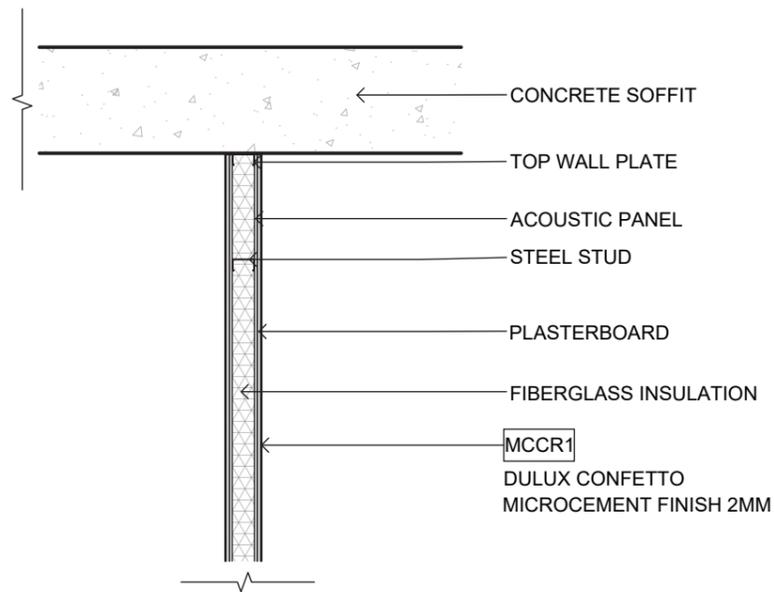

01 INTERIOR WALL DETAILS  
A11 1:20

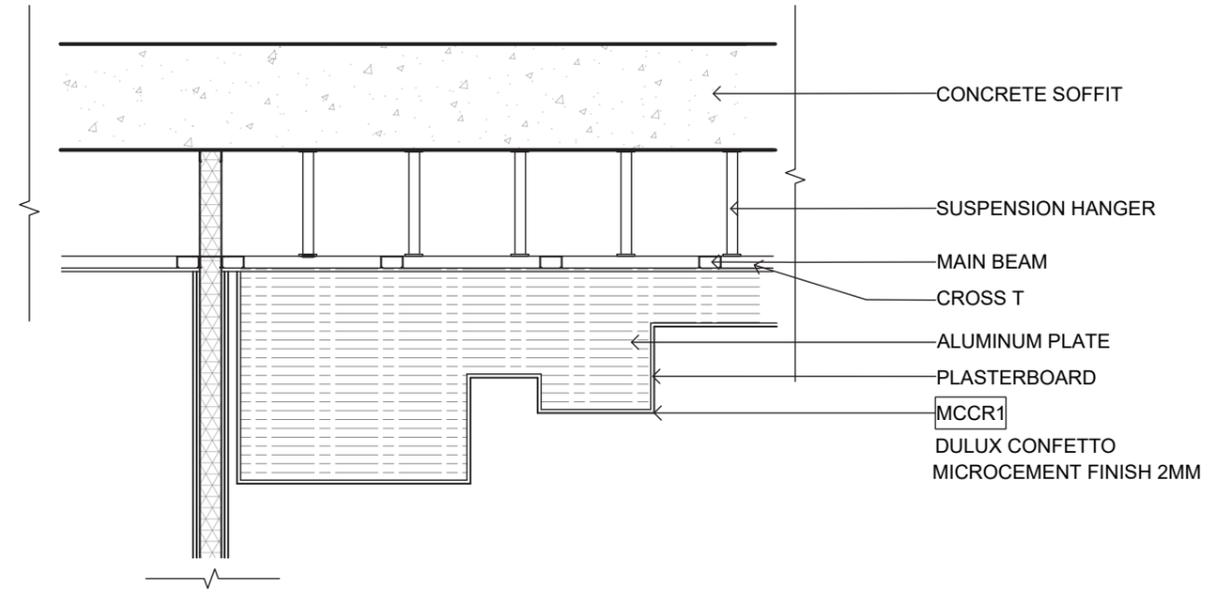

02 CEILING DETAILS  
A11 1:20



STUDIO GAIA  
1234 5678  
interiors@studiogaia.com.au  
www.studiogaia.com.au

NOTES:

CLIENT:

LUCY MAJOR  
lucymajor@gmail.com  
0412 345 678

STAGE:

FOR TENDER

DATE:15-08-2024

TITLE:

CEILING DETAILS

SCALE: 1:20

PROJECT:

KARLJINI SKINCARE RETAIL FIT OUT  
1-1253 ZONE 12, GROUND LEVEL  
WESTFIELD CAROUSEL, CANNINGTON WA 6107



DRAWN BY:

STUDIO GAIA

REVISION:


NONE

**A11**

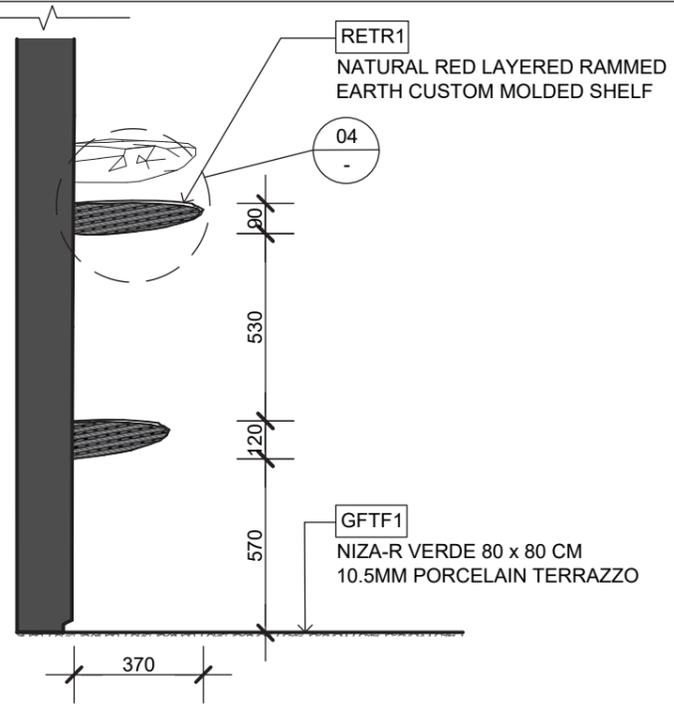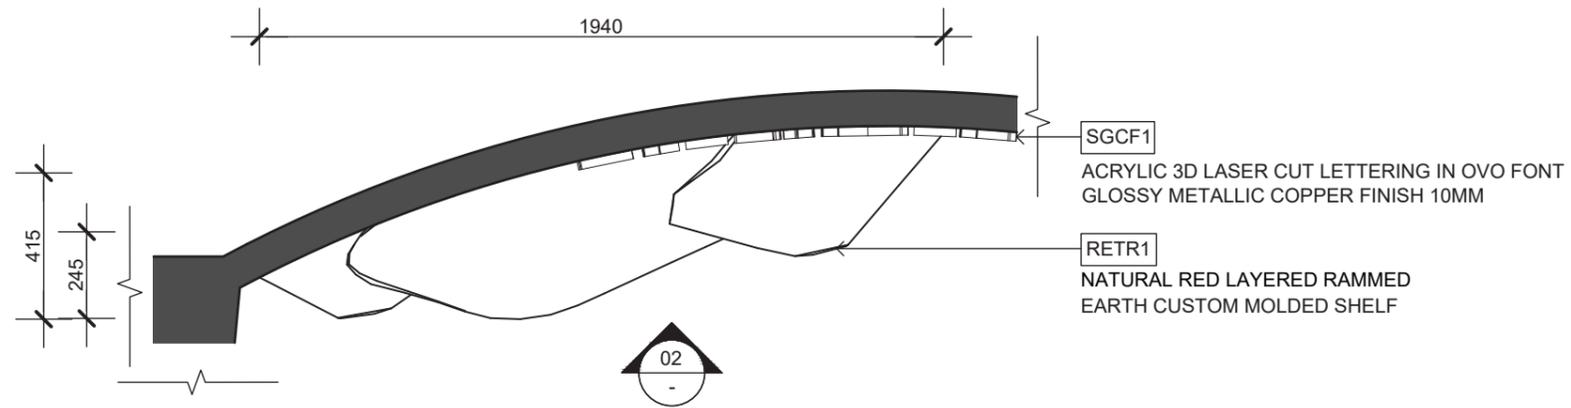


01 RAMMED EARTH SHELF PLAN  
A12 1:20

03 RAMMED EARTH SHELF SECTION  
A12 1:20

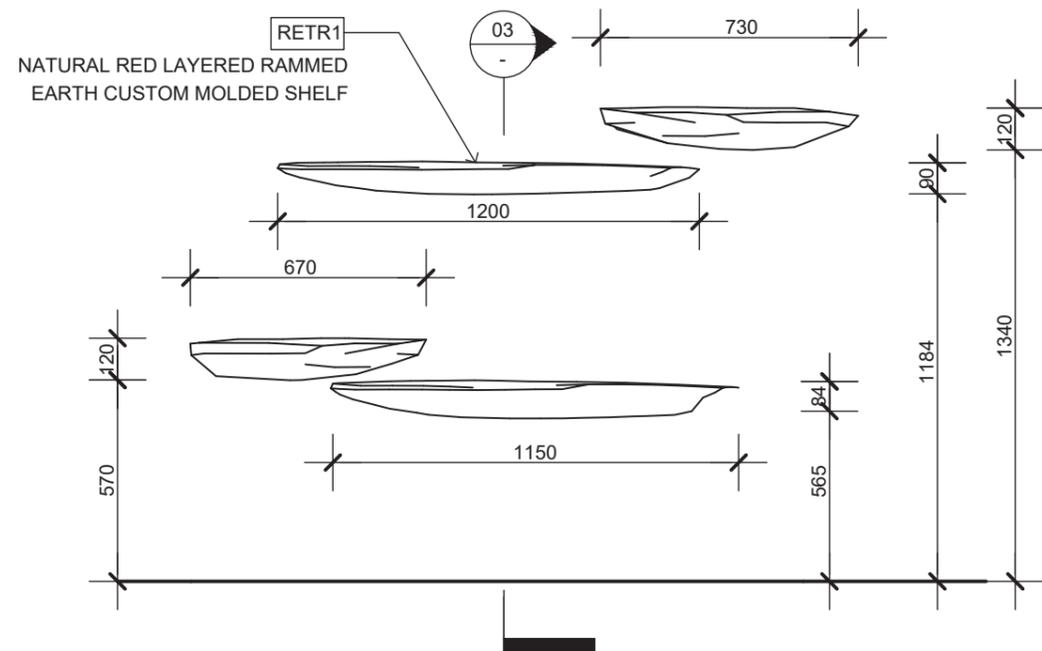

02 RAMMED EARTH SHELF ELEVATION  
A12 1:20

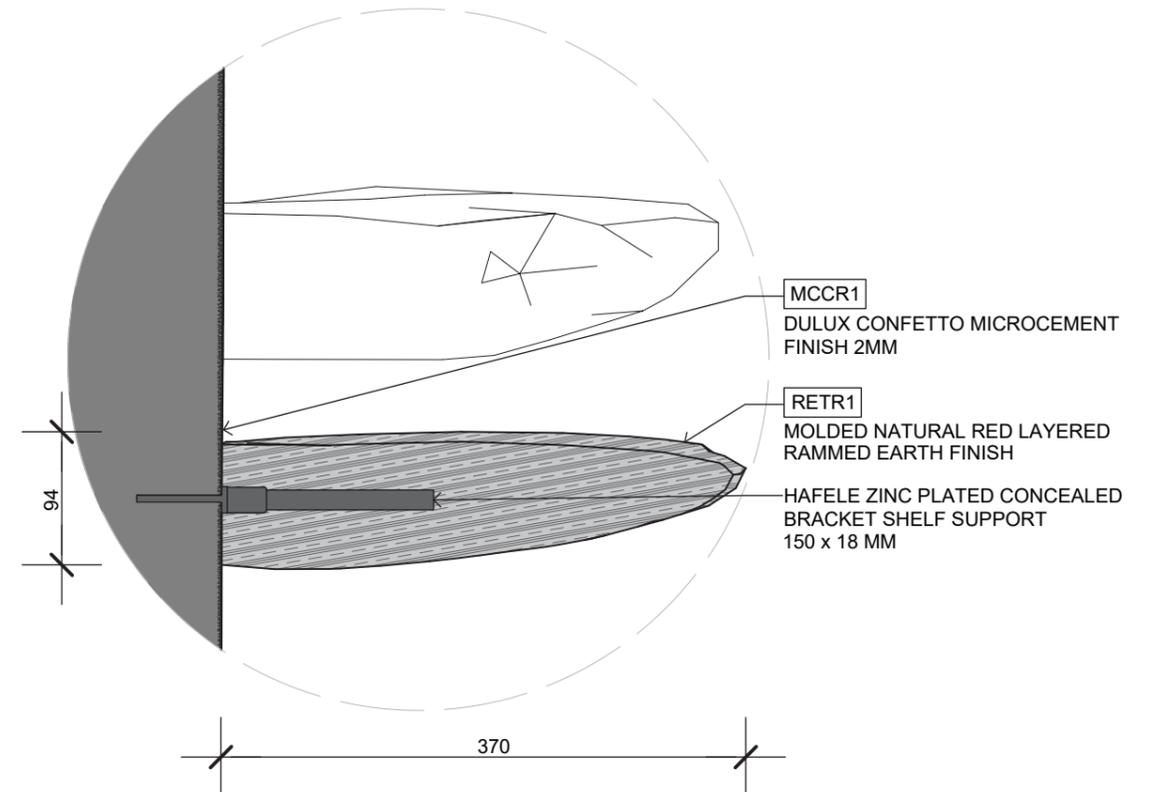

04 RAMMED EARTH SHELF DETAIL  
A12 1:5



STUDIO GAIA  
1234 5678  
interiors@studiogaia.com.au  
www.studiogaia.com.au

NOTES:

CLIENT:

LUCY MAJOR  
lucymajor@email.com  
0412 345 678

STAGE:

FOR TENDER

DATE:15-08-2024

TITLE:

JOINERY DETAILS - SHEET ONE

VARIOUS SCALES

PROJECT:

KARLJINI SKINCARE RETAIL FIT OUT  
1-1253 ZONE 12, GROUND LEVEL  
WESTFIELD CAROUSEL, CANNINGTON WA 6107


DRAWN BY:

STUDIO GAIA

REVISION:

NONE

A12

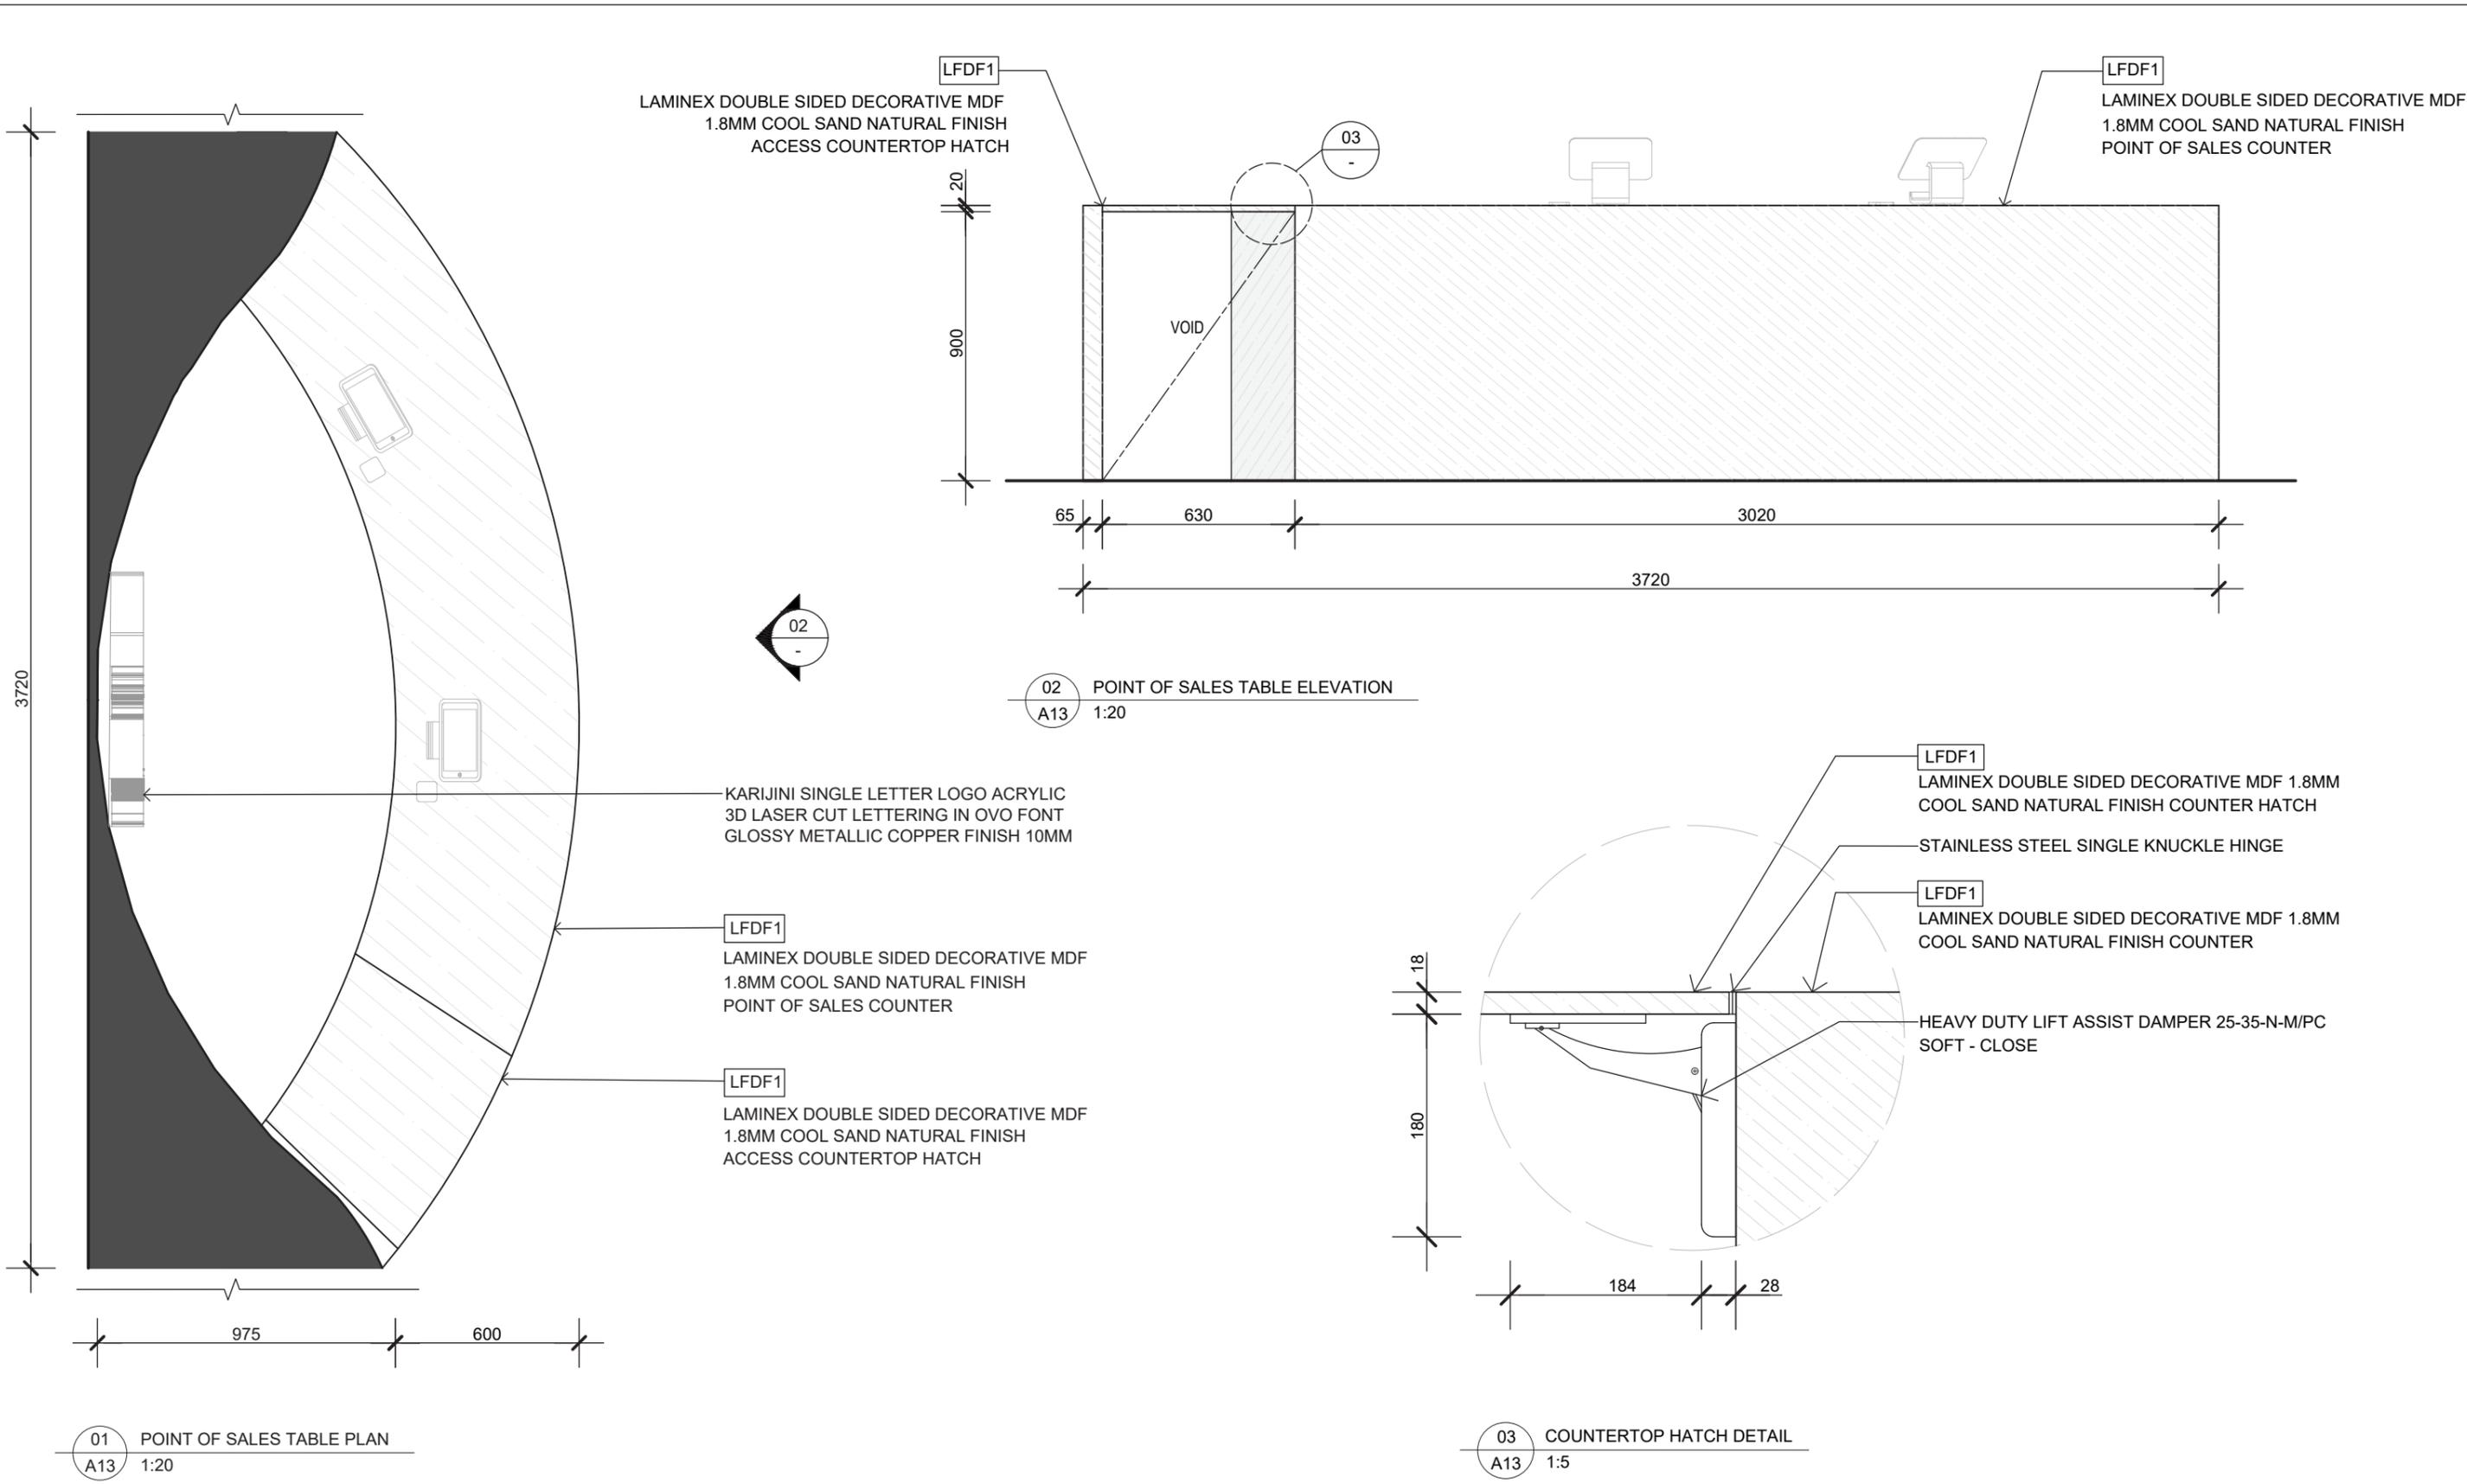

**STUDIO GAIA**  
1234 5678  
interiors@studiogaia.com.au  
www.studiogaia.com.au


NOTES:

CLIENT: LUCY MAJOR  
lucymajor@email.com  
0412 345 678

PROJECT: KARIJINI SKINCARE RETAIL FIT OUT  
1-1253 ZONE 12, GROUND LEVEL  
WESTFIELD CAROUSEL, CANNINGTON WA 6107

STAGE:	FOR TENDER	DATE: 15-08-2024
TITLE:	JOINERY DETAILS - SHEET TWO	VARIOUS SCALES
DRAWN BY:	STUDIO GAIA	<b>A13</b>
REVISION:	NONE	






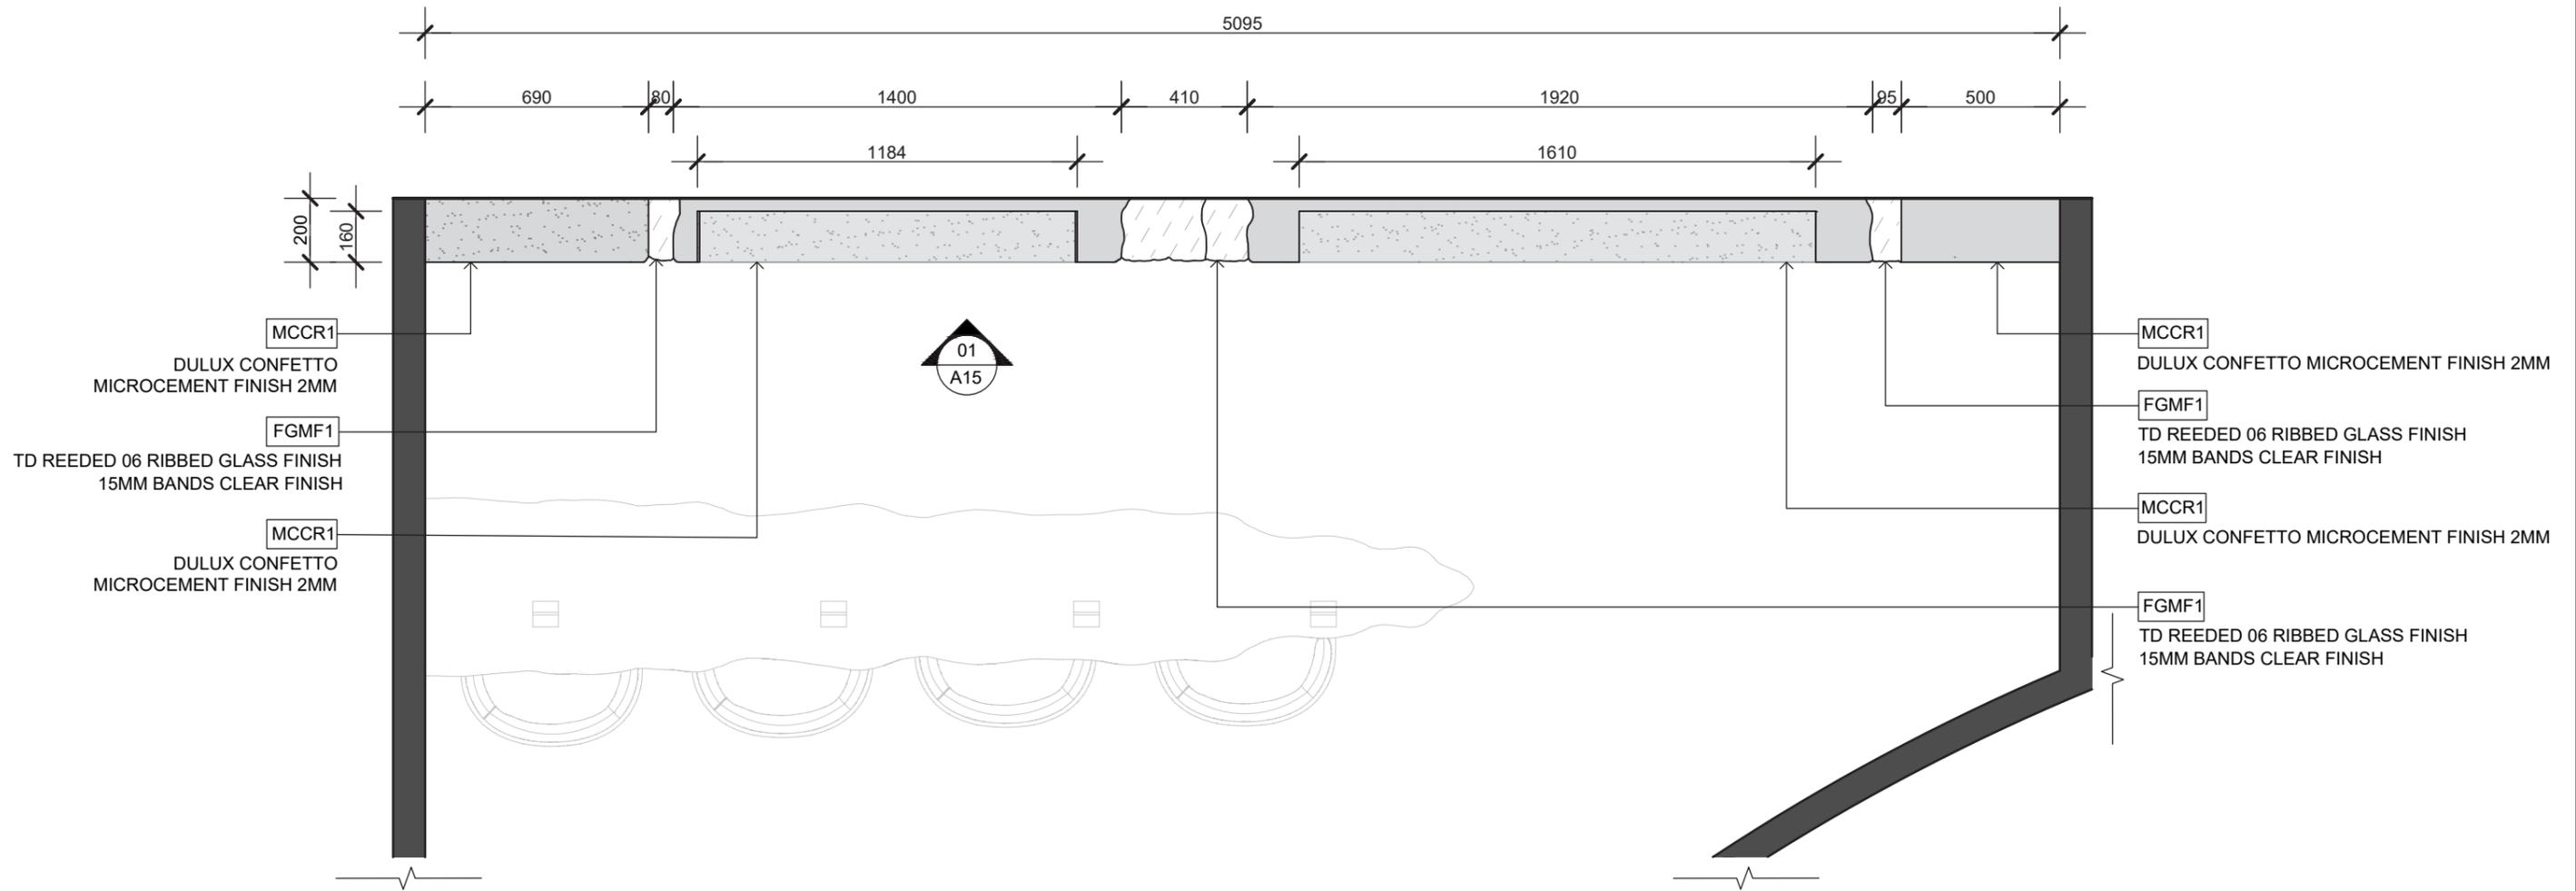

01 CONSULTATION SHELVING PLAN  
A14 1:20

 <p>STUDIO GAIA 1234 5678 interiors@studiogaia.com.au www.studiogaia.com.au</p>	NOTES:	CLIENT:	LUCY MAJOR lucymajor@email.com 0412 345 678	STAGE:	FOR TENDER	DATE:15-08-2024
		PROJECT:	KARLJINI SKINCARE RETAIL FIT OUT 1-1253 ZONE 12, GROUND LEVEL WESTFIELD CAROUSEL, CANNINGTON WA 6107	TITLE:	JOINERY DETAILS - SHEET THREE	SCALE: 1:20
				DRAWN BY:	STUDIO GAIA	A14
		REVISION:	NONE			

01  
A16

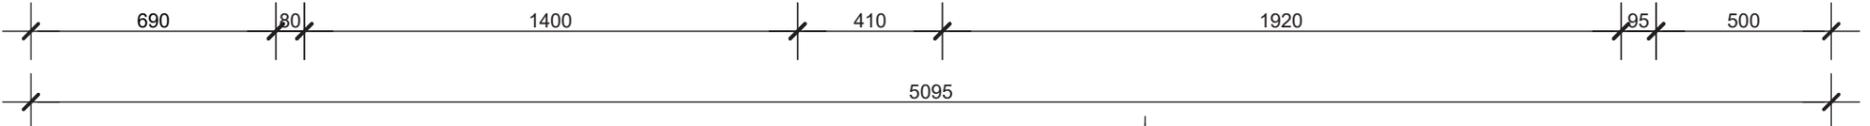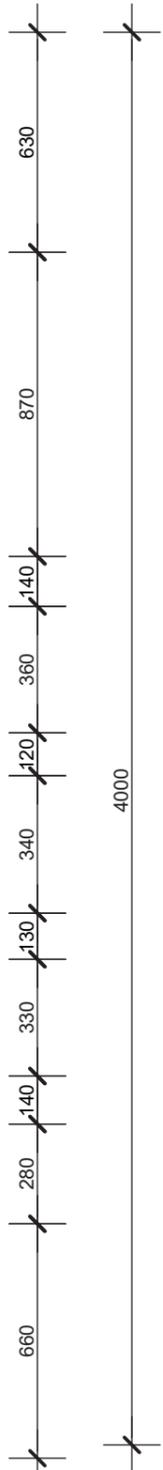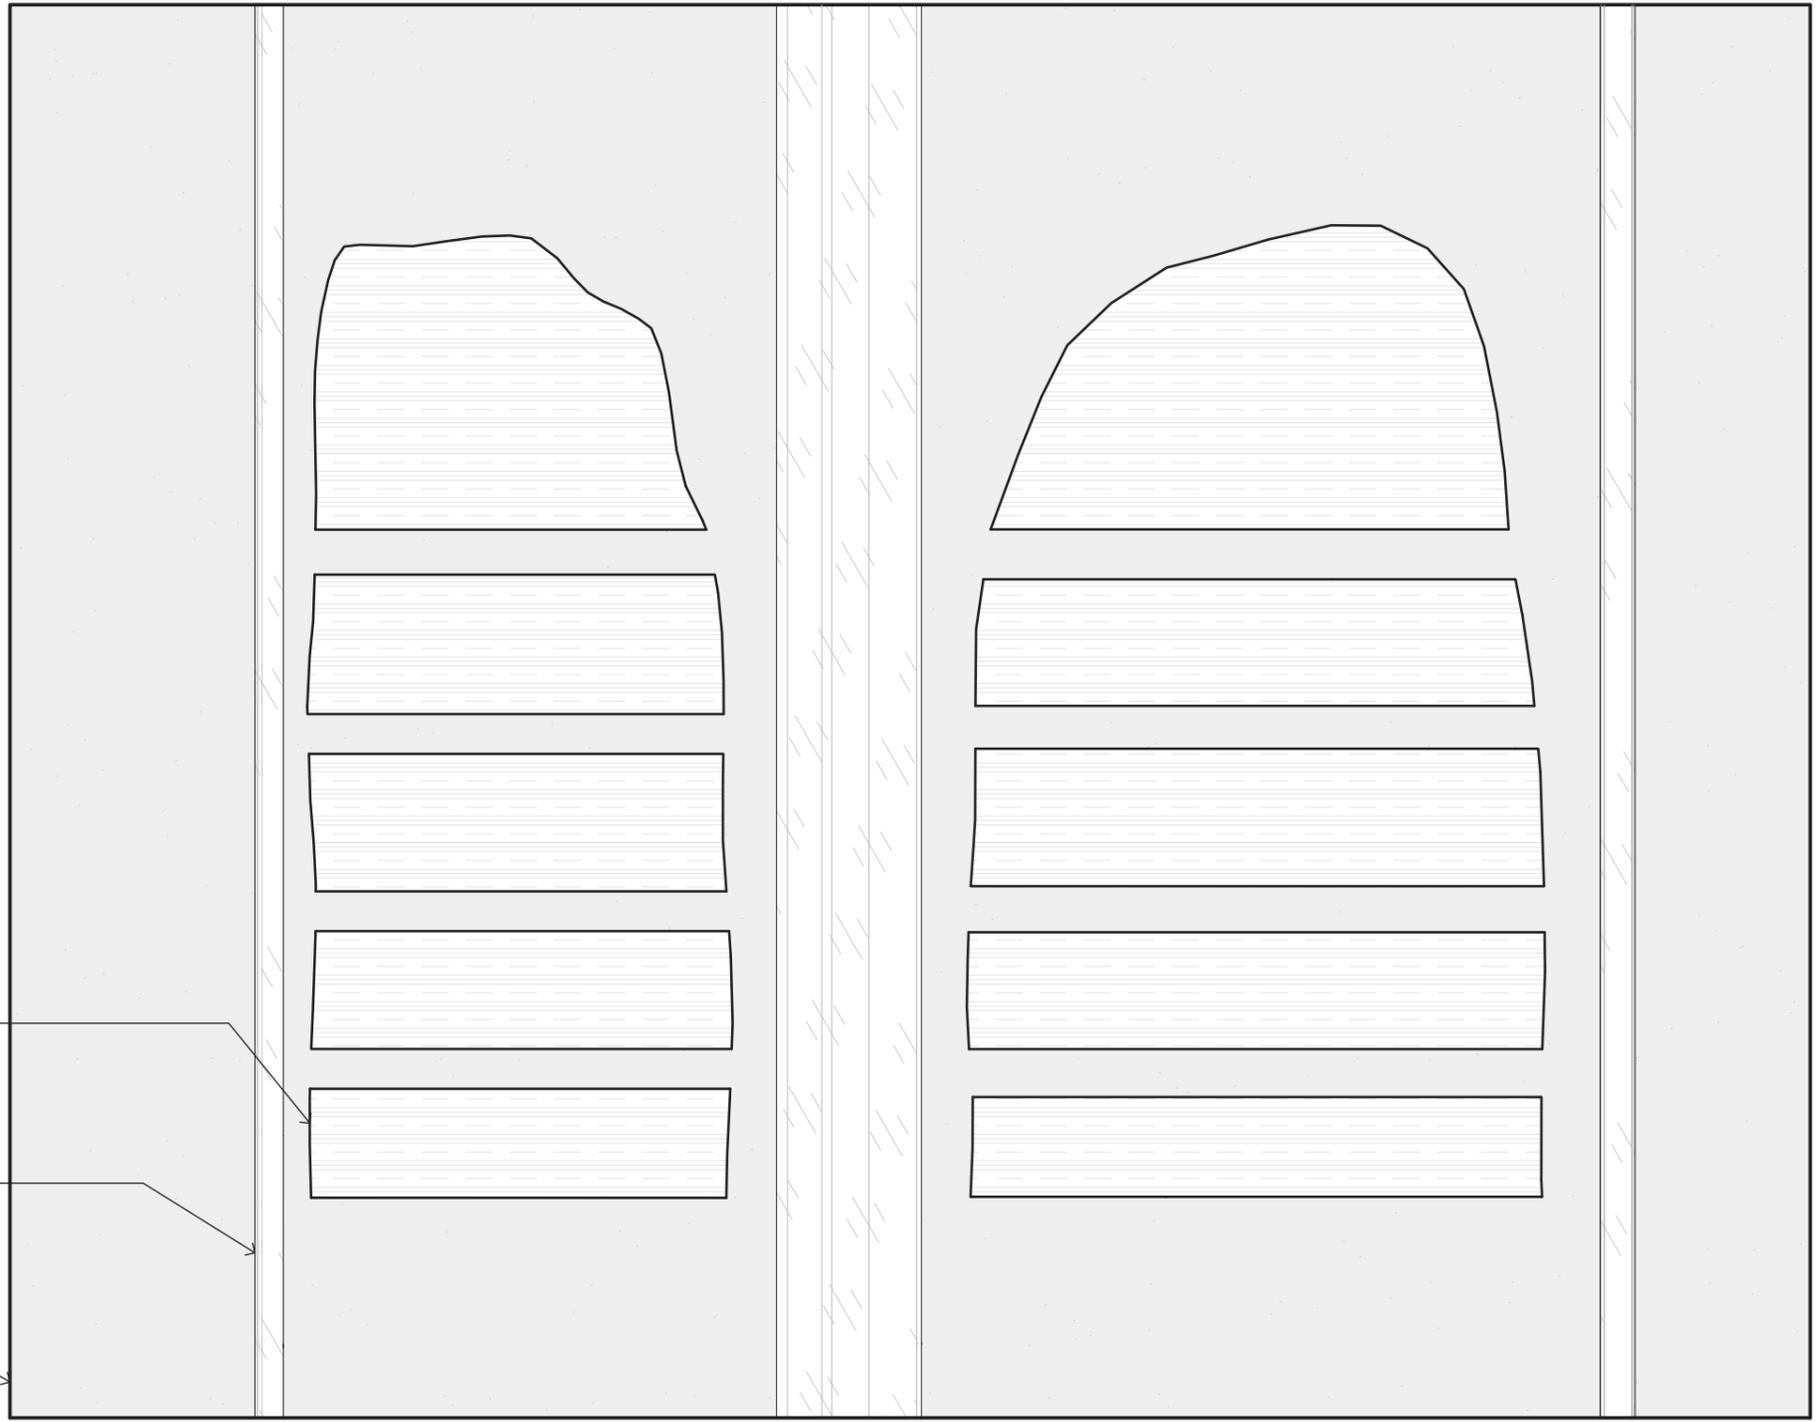


RETR2  
CUSTOM WARM TONED LAYERED  
RAMMED EARTH FINISH

FGMF1  
TD REEDED 06 RIBBED GLASS FINISH  
15MM BANDS CLEAR FINISH


MCCR1  
DULUX CONFETTO  
MICROCEMENT FINISH 2MM

01 CONSULTATION SHELVING ELEVATION  
A15 1:20

	STUDIO GAIA	NOTES:	CLIENT:	LUCY MAJOR lucymajor@email.com 0412 345 678	STAGE:	FOR TENDER	DATE:15-08-2024	
	1234 5678 interiors@studiogaia.com.au www.studiogaia.com.au		PROJECT:	KARLJINI SKINCARE RETAIL FIT OUT 1-1253 ZONE 12, GROUND LEVEL WESTFIELD CAROUSEL, CANNINGTON WA 6107	TITLE:	JOINERY DETAILS - SHEET FOUR	SCALE: 1:20	
				DRAWN BY:	STUDIO GAIA	REVISION:	NONE	A15

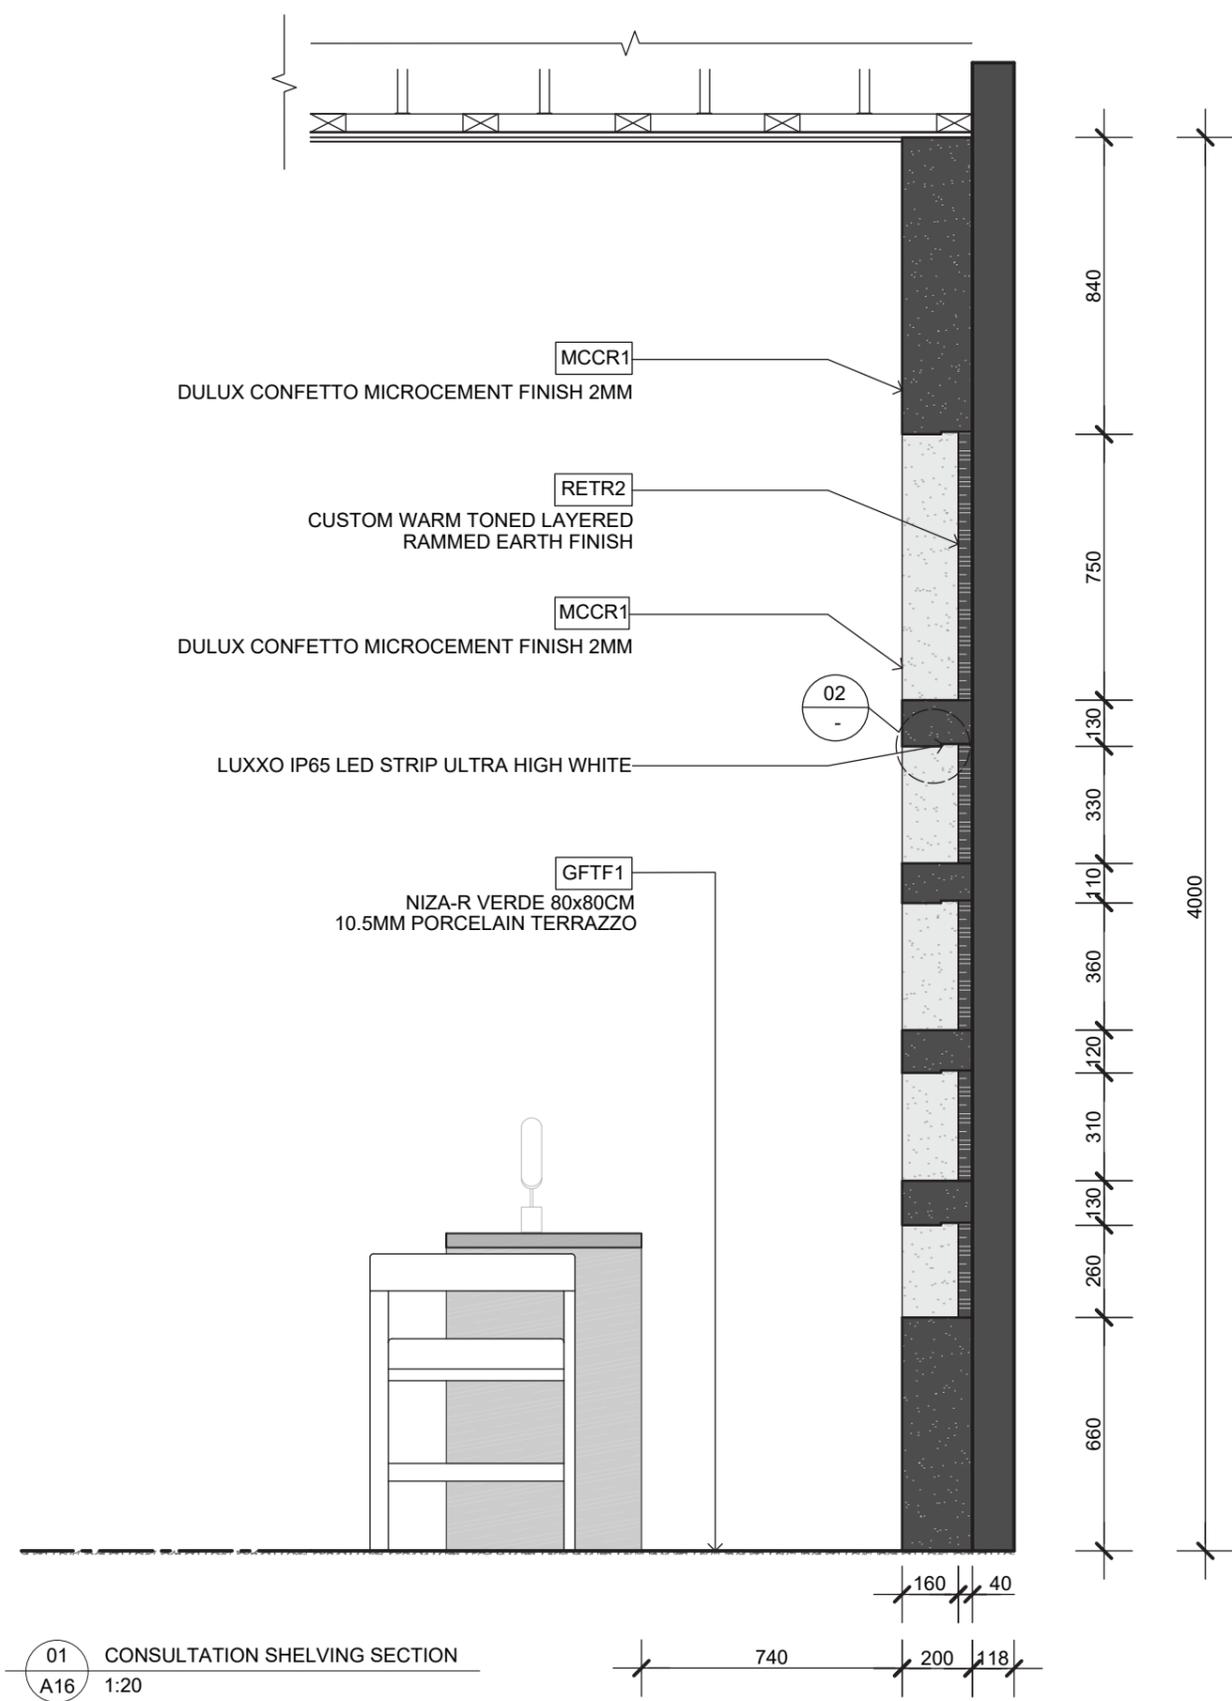

01 CONSULTATION SHELVING SECTION  
A16 1:20

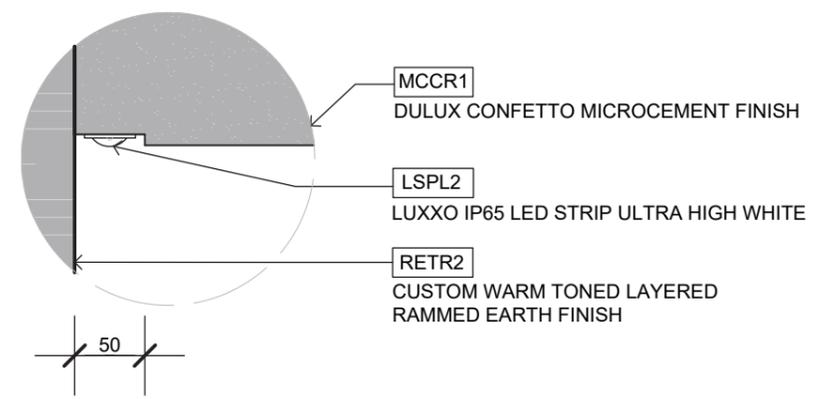

02 RECESSED LED LIGHTING DETAIL  
A16 1:5




STUDIO GAIA  
1234 5678  
interiors@studiogaia.com.au  
www.studiogaia.com.au

NOTES:


CLIENT: LUCY MAJOR  
lucymajor@email.com  
0412 345 678

PROJECT: KARLJINI SKINCARE RETAIL FIT OUT  
1-1253 ZONE 12, GROUND LEVEL  
WESTFIELD CAROUSEL, CANNINGTON WA 6107


STAGE:	FOR TENDER	DATE: 15-08-2024
TITLE:	JOINERY DETAILS - SHEET FIVE	VARIOUS SCALES
DRAWN BY:	STUDIO GAIA	<b>A16</b>
REVISION:	NONE	

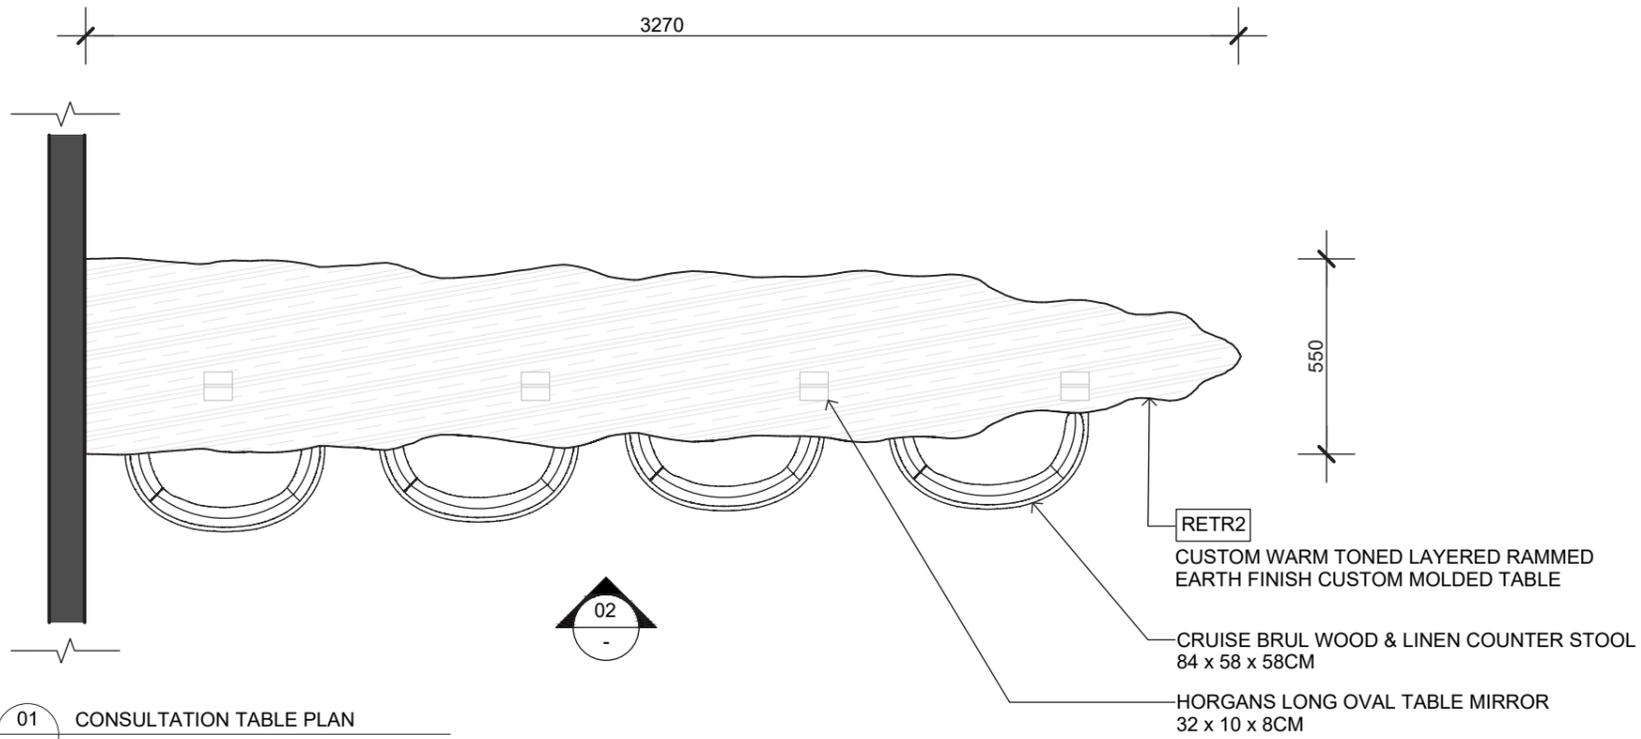

01 CONSULTATION TABLE PLAN  
A17 1:20

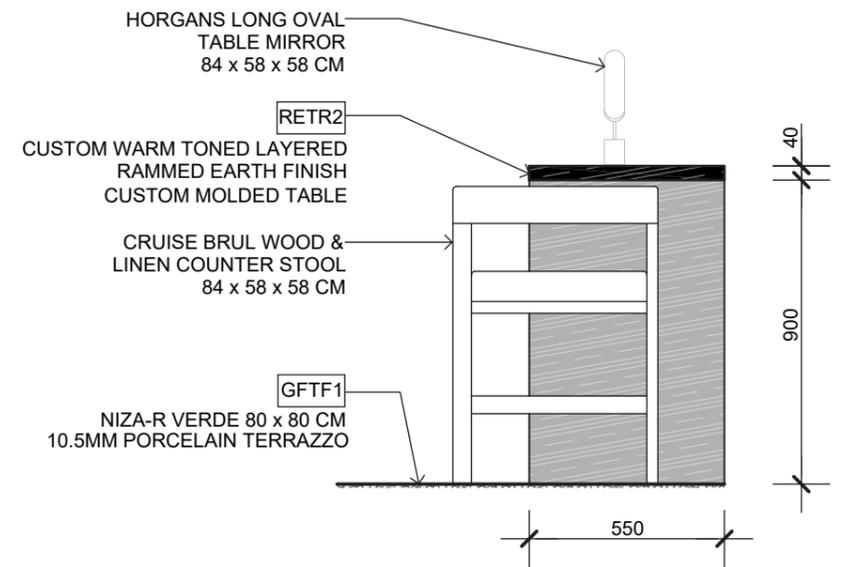

03 CONSULTATION TABLE SECTION  
A17 1:20

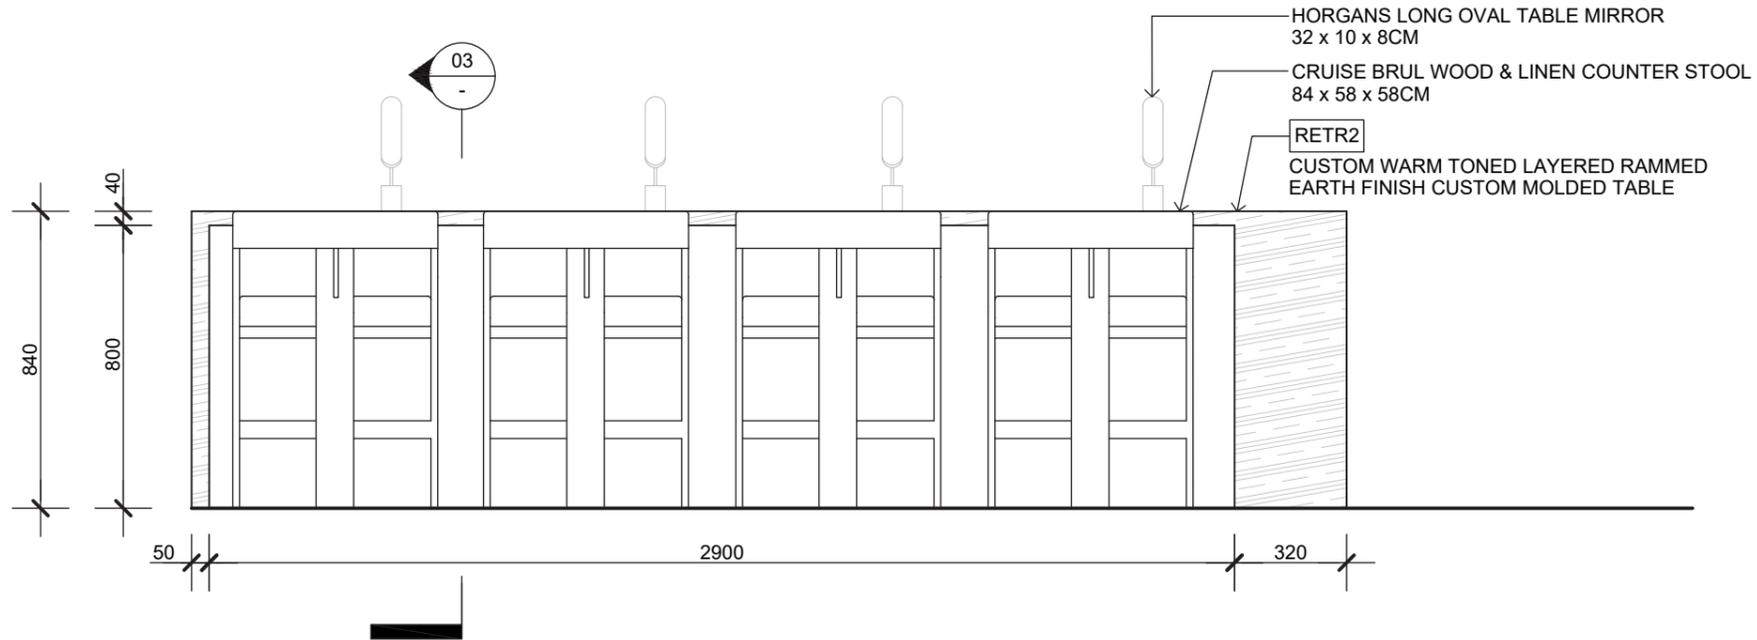

02 CONSULTATION TABLE ELEVATION  
A17 1:20



STUDIO GAIA  
1234 5678  
interiors@studiogaia.com.au  
www.studiogaia.com.au

NOTES:

CLIENT:

LUCY MAJOR  
lucymajor@email.com  
0412 345 678

STAGE:

FOR TENDER

DATE:15-08-2024

TITLE:

JOINERY DETAILS - SHEET SIX

SCALE: 1:20

PROJECT:

KARLJINI SKINCARE RETAIL FIT OUT  
1-1253 ZONE 12, GROUND LEVEL  
WESTFIELD CAROUSEL, CANNINGTON WA 6107

DRAWN BY:

STUDIO GAIA

REVISION:

NONE


**A17**

RETR2  
CUSTOM WARM TONED LAYERED RAMMED  
EARTH CUSTOM MOLDED STONE

DSFF2  
TRADITIONAL STONE MIX  
PEARL FINISH 3MM

RETR1  
NATURAL RED LAYERED  
RAMMED EARTH PATTERNED  
FINISH ROUGH TEXTURE

TSUG2  
TOUGHENED GLASS  
ULTRA TEMPERED  
12MM ULTRA CLEAR

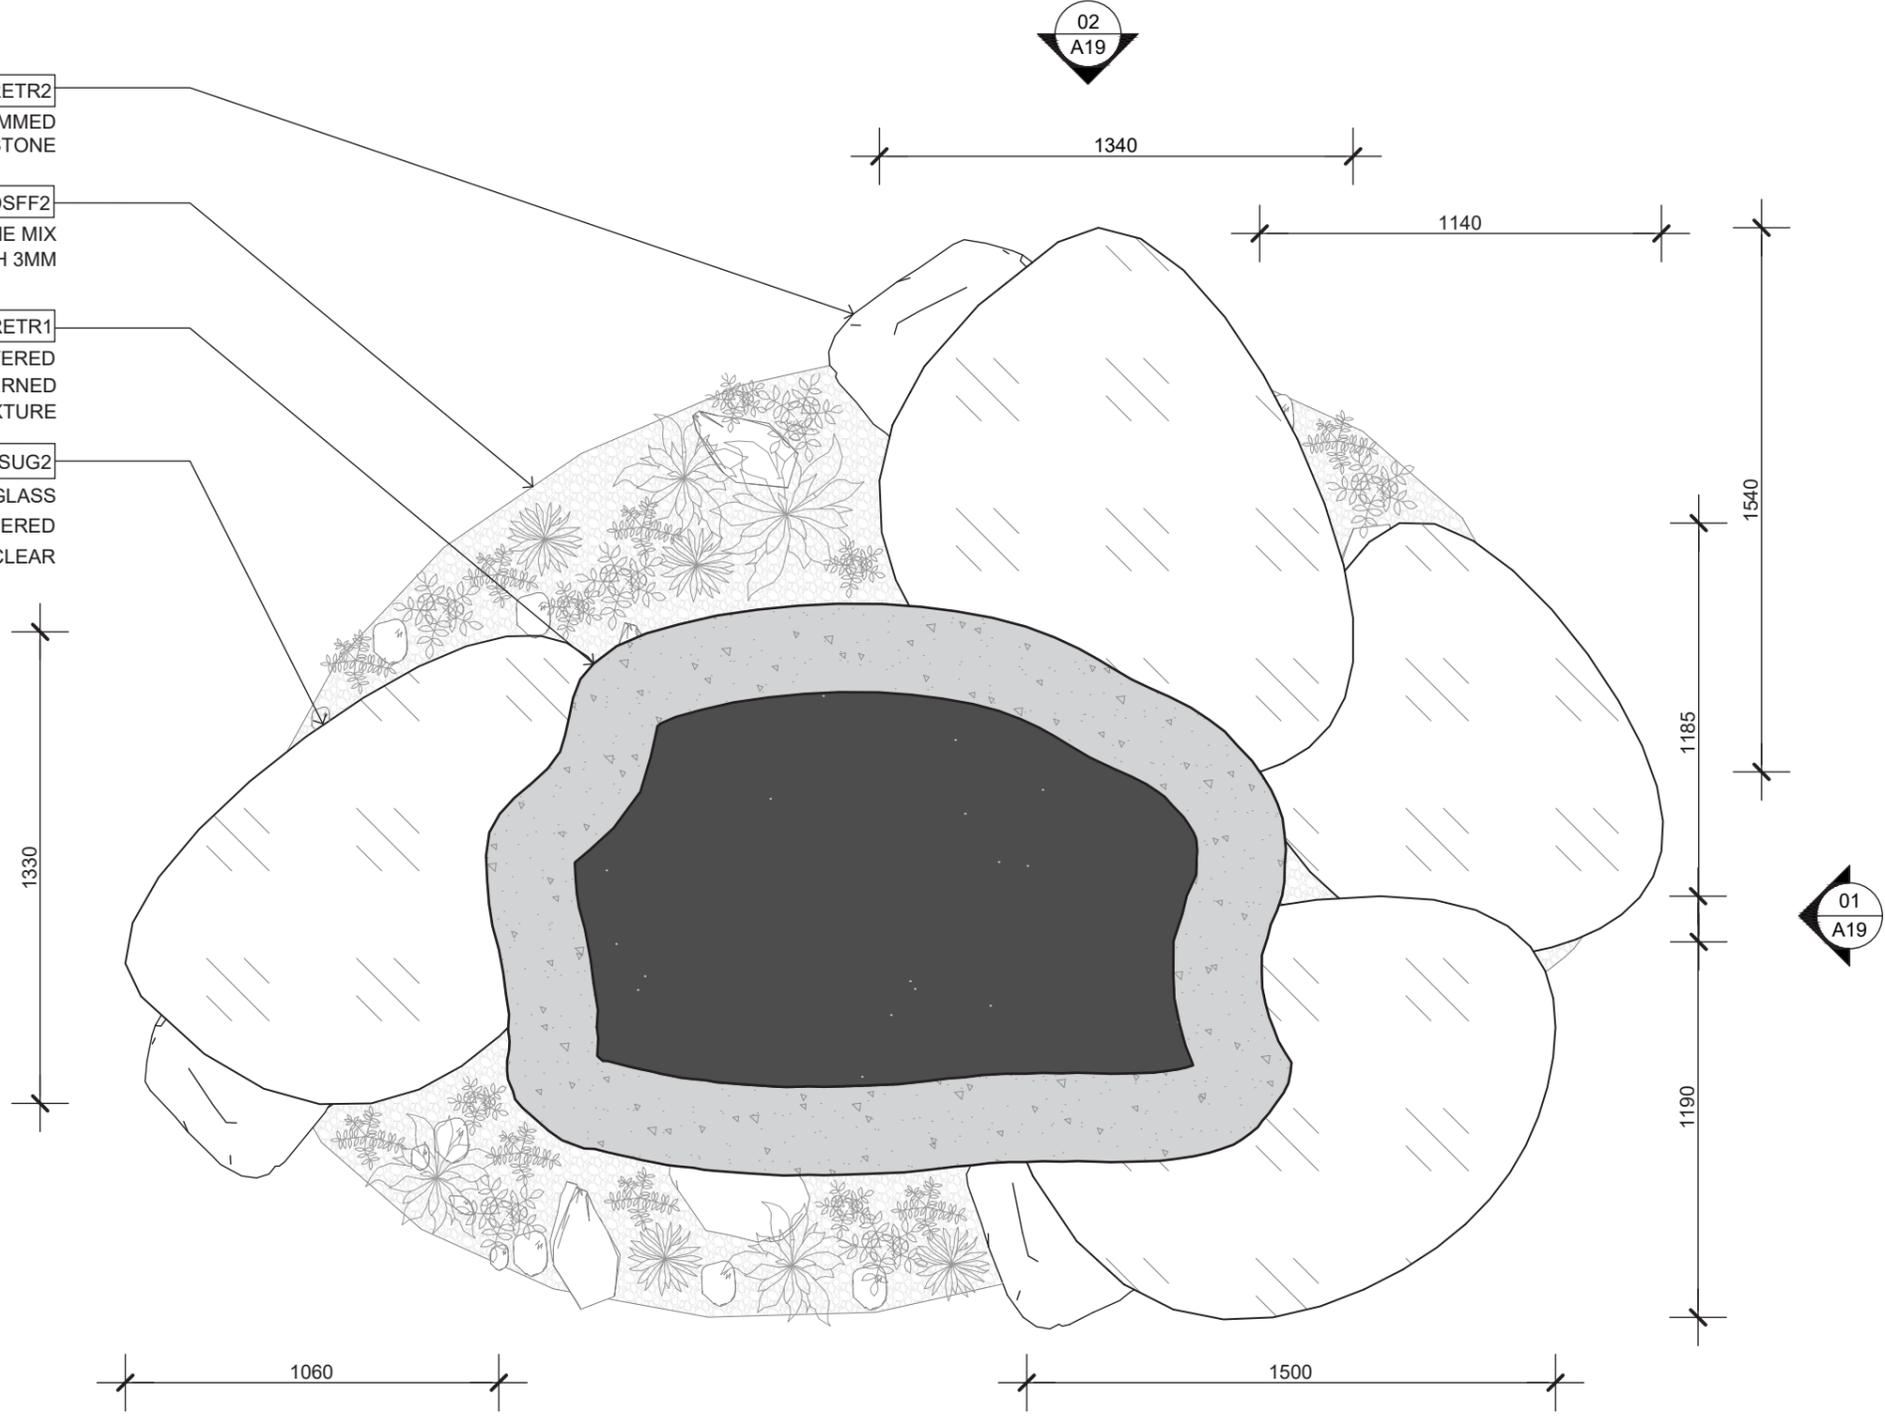

01 CUSTOM GLASS TABLES PLAN  
A18 1:20



STUDIO GAIA  
1234 5678  
interiors@studiogaia.com.au  
www.studiogaia.com.au

NOTES:

CLIENT:

LUCY MAJOR  
lucymajor@email.com  
0412 345 678

STAGE:

FOR TENDER

DATE:15-08-2024

TITLE:

JOINERY DETAILS - SHEET SEVEN

SCALE: 1:20

PROJECT:

KARLINI SKINCARE RETAIL FIT OUT  
1-1253 ZONE 12, GROUND LEVEL  
WESTFIELD CAROUSEL, CANNINGTON WA 6107


DRAWN BY:

STUDIO GAIA


REVISION:

NONE


**A18**

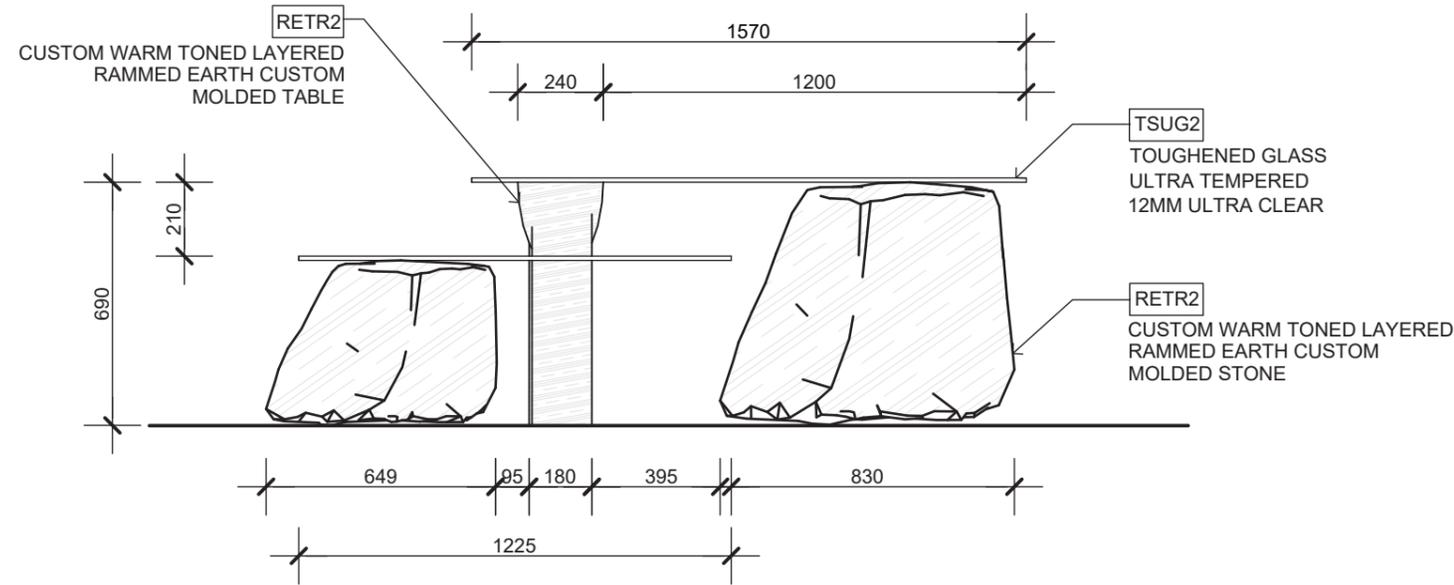

01 CUSTOM GLASS TABLES NORTH ELEVATION  
A19 1:20

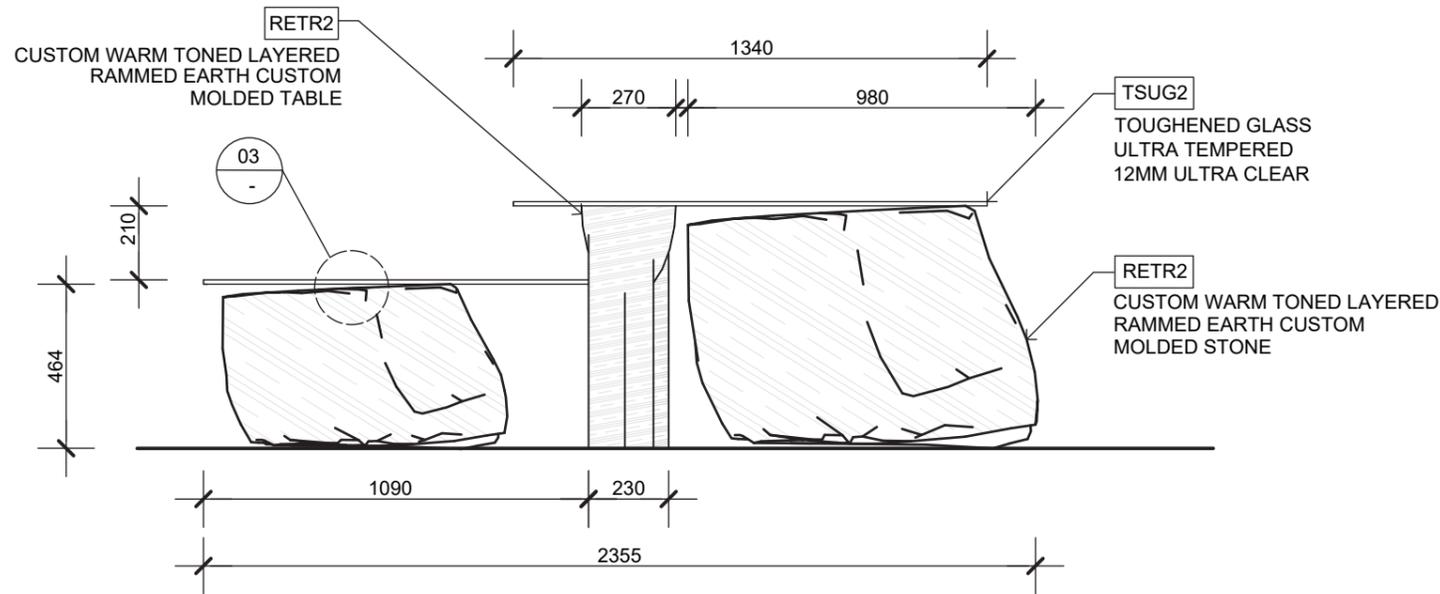

02 CUSTOM GLASS TABLES WEST ELEVATION  
A19 1:20

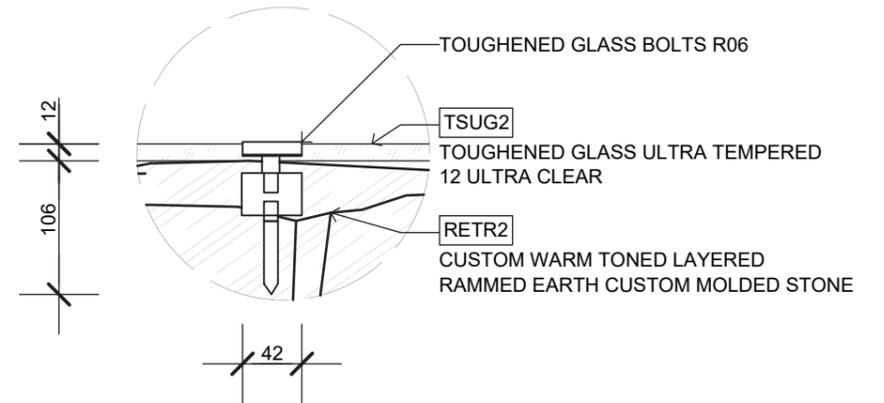

03 CUSTOM GLASS TABLE DETAIL  
A19 1:5



STUDIO GAIA  
1234 5678  
interiors@studiogaia.com.au  
www.studiogaia.com.au

NOTES:

CLIENT:

LUCY MAJOR  
lucymajor@gmail.com  
0412 345 678

STAGE:

FOR TENDER

DATE:15-08-2024

TITLE:

JOINERY DETAILS - SHEET EIGHT

VARIOUS SCALES

PROJECT:

KARLJINI SKINCARE RETAIL FIT OUT  
1-1253 ZONE 12, GROUND LEVEL  
WESTFIELD CAROUSEL, CANNINGTON WA 6107

DRAWN BY:



STUDIO GAIA

REVISION:

NONE

A19



01  
A21

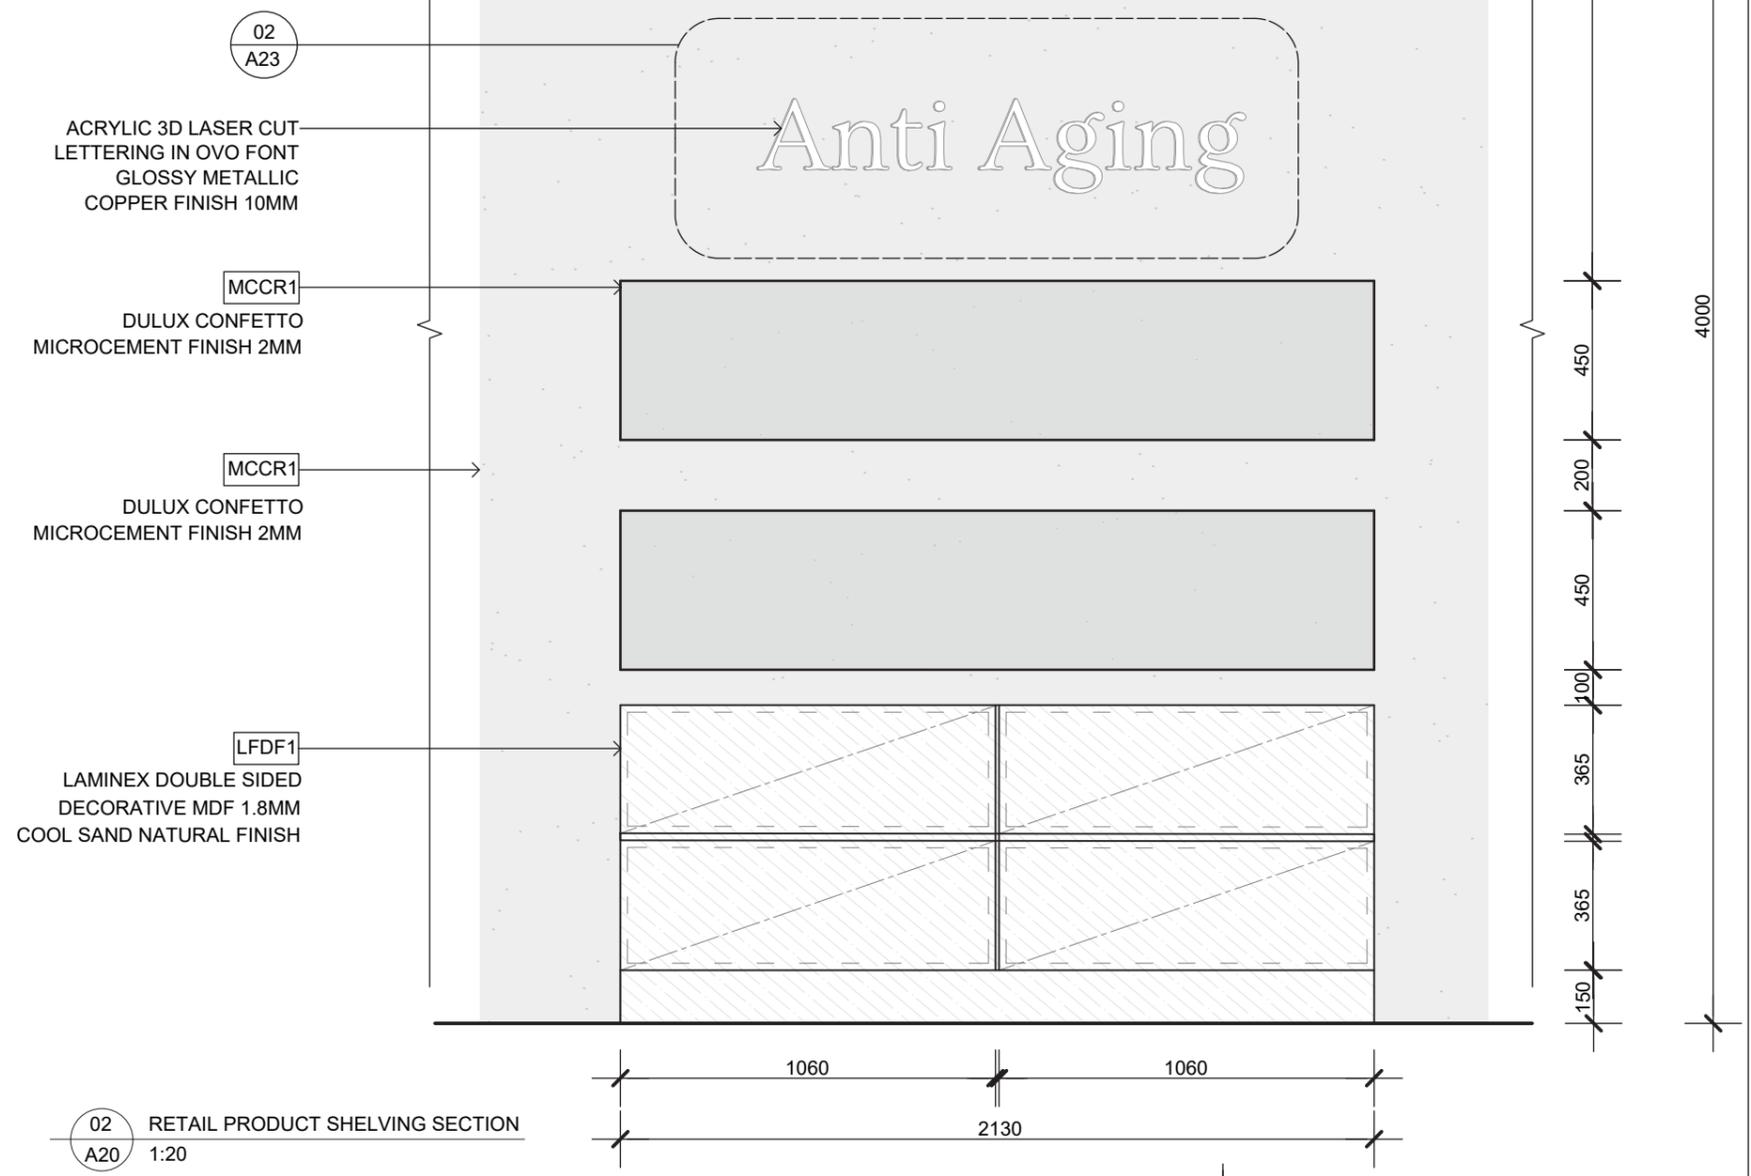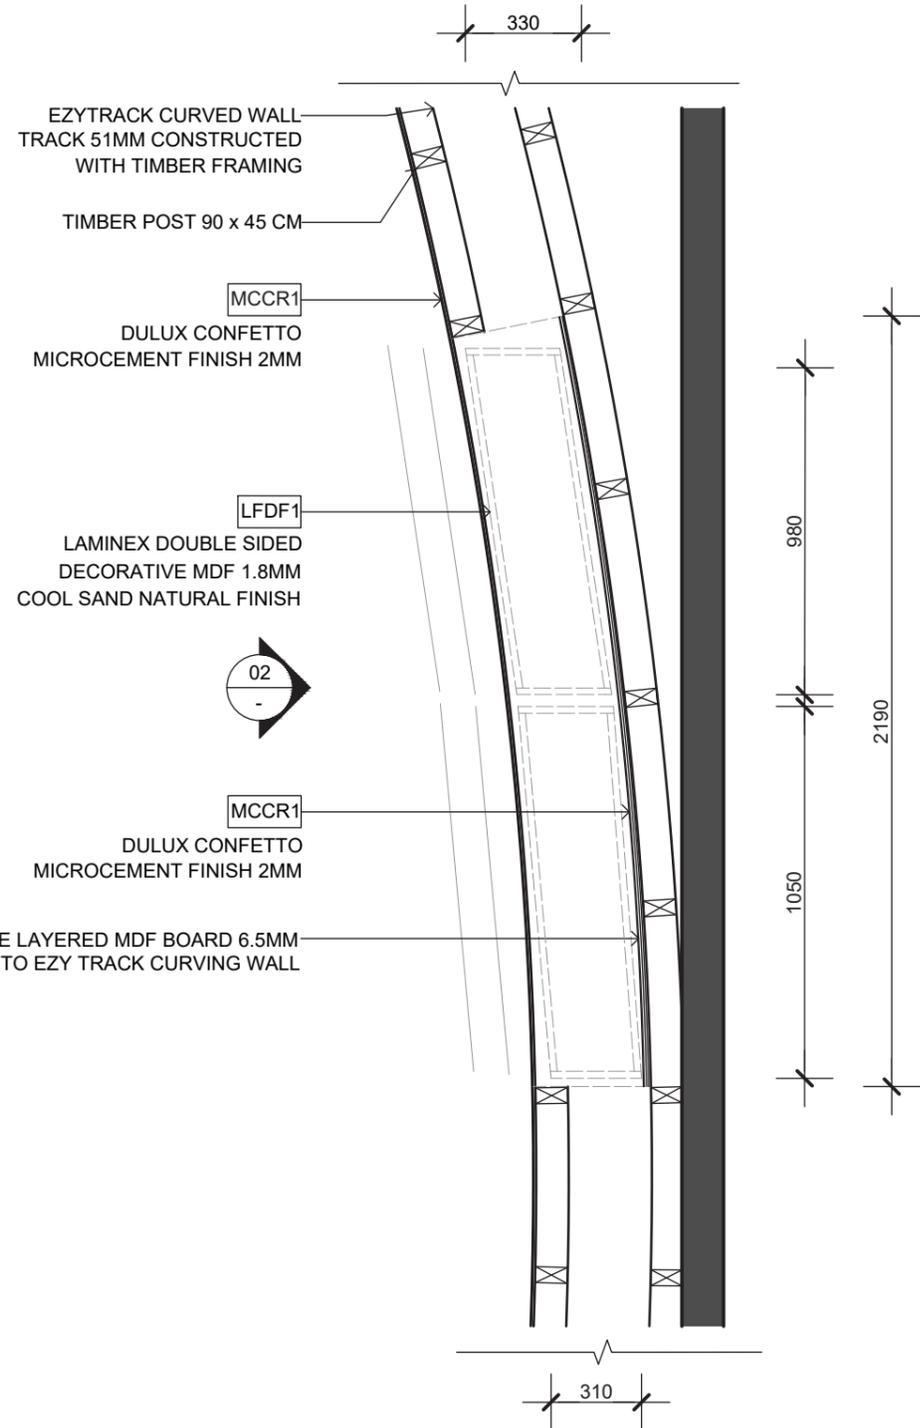

01 RETAIL PRODUCT SHELVING PLAN  
A20 1:20

02 RETAIL PRODUCT SHELVING SECTION  
A20 1:20

	STUDIO GAIA	NOTES:	CLIENT:	LUCY MAJOR lucymajor@email.com 0412 345 678	STAGE:	FOR TENDER	DATE: 15-08-2024
	1234 5678 interiors@studiogaia.com.au www.studiogaia.com.au		PROJECT:	KARLINI SKINCARE RETAIL FIT OUT 1-1253 ZONE 12, GROUND LEVEL WESTFIELD CAROUSEL, CANNINGTON WA 6107	TITLE:	JOINERY DETAILS - SHEET NINE	SCALE: 1:20
				DRAWN BY:	STUDIO GAIA	A20	
				REVISION:	NONE		

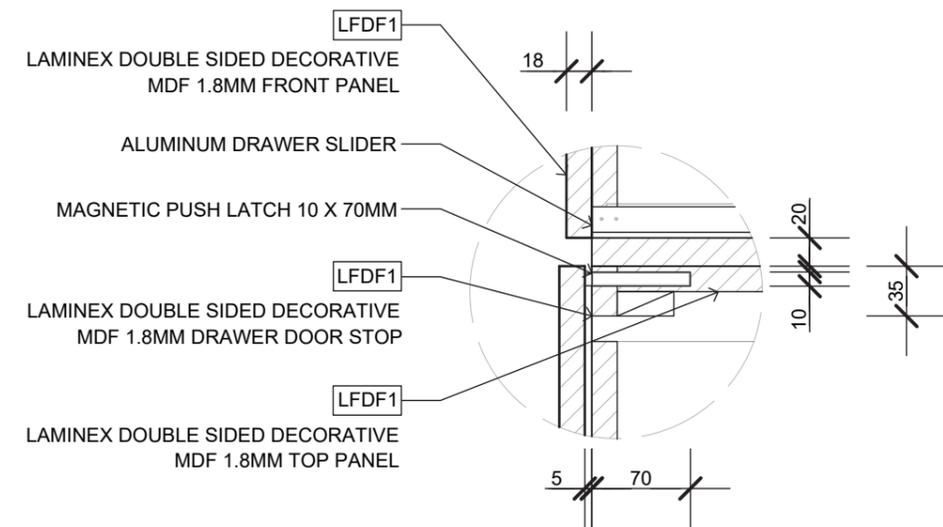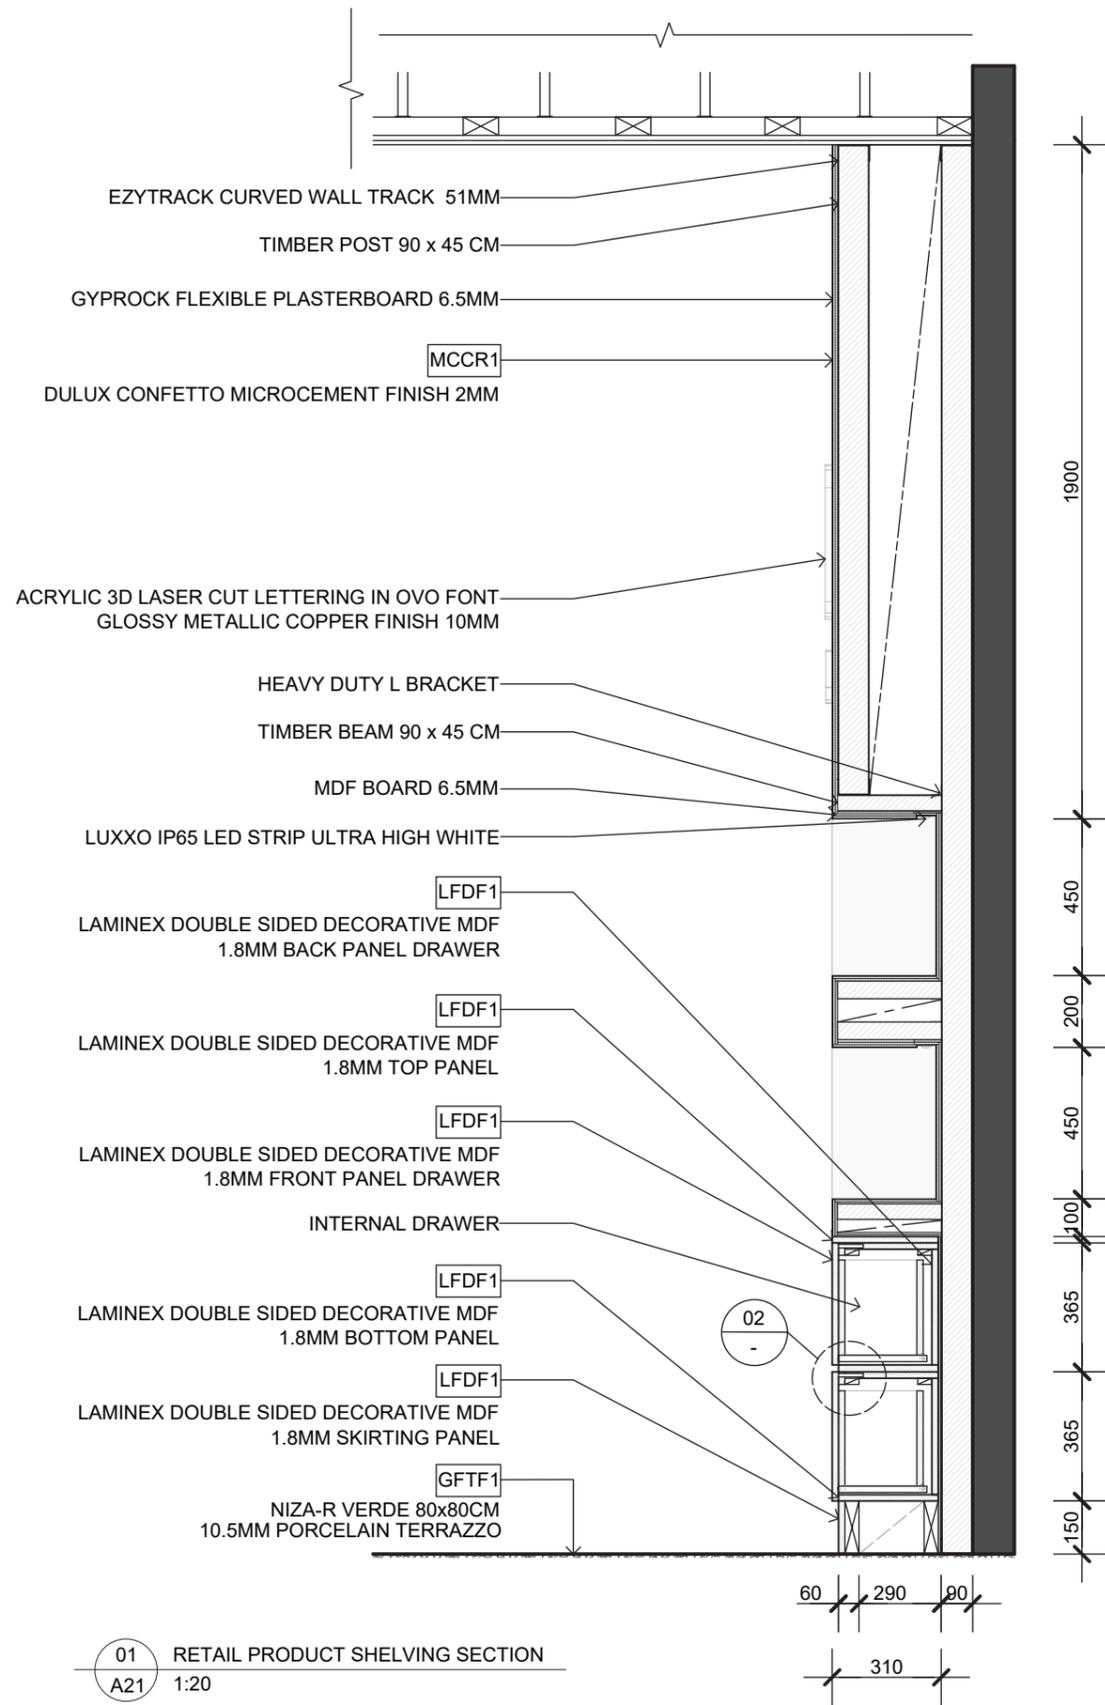

02 DRAWER HANDLE DETAIL  
 A21 1:5



STUDIO GAIA  
 1234 5678  
 interiors@studiogaia.com.au  
 www.studiogaia.com.au

NOTES:

CLIENT:

LUCY MAJOR  
 lucymajor@email.com  
 0412 345 678

STAGE:

FOR TENDER

DATE:15-08-2024

TITLE:

JOINERY DETAILS - SHEET TEN

VARIOUS SCALES

PROJECT:

KARLJINI SKINCARE RETAIL FIT OUT  
 1-1253 ZONE 12, GROUND LEVEL  
 WESTFIELD CAROUSEL, CANNINGTON WA 6107


DRAWN BY:

STUDIO GAIA


REVISION:

NONE


A21

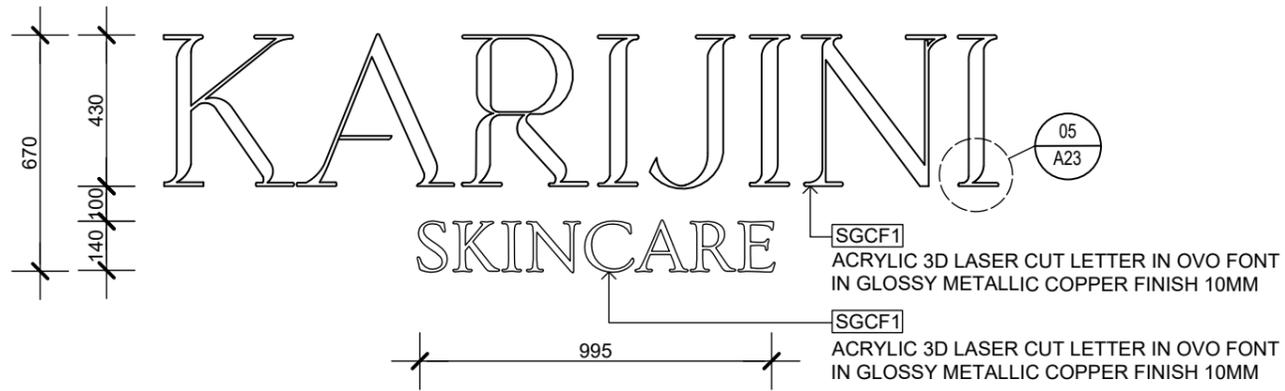


01 KARIJINI LOGO SIGNAGE DETAIL  
A22 1:20

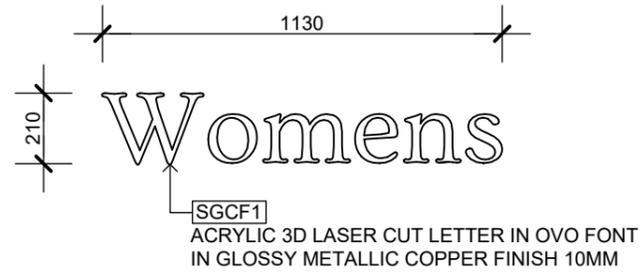


03 WOMENS SIGNAGE DETAIL  
A22 1:20

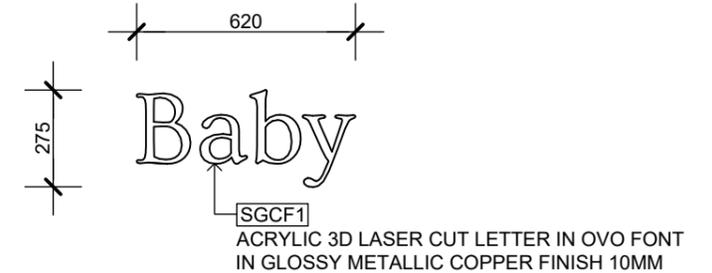


05 BABY SIGNAGE DETAIL  
A22 1:20

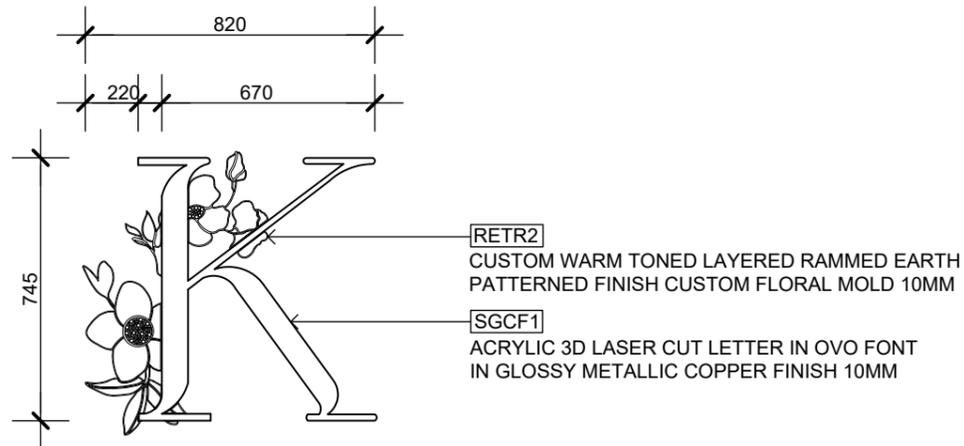

02 K LETTERING SIGNAGE DETAIL  
A22 1:20

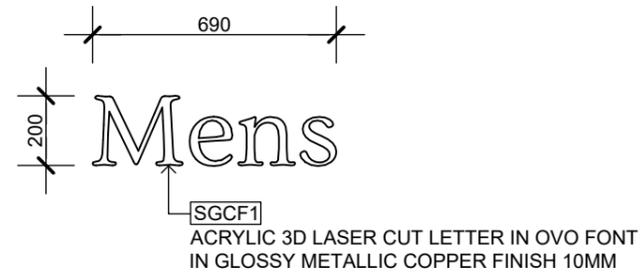

04 MENS SIGNAGE DETAIL  
A22 1:20

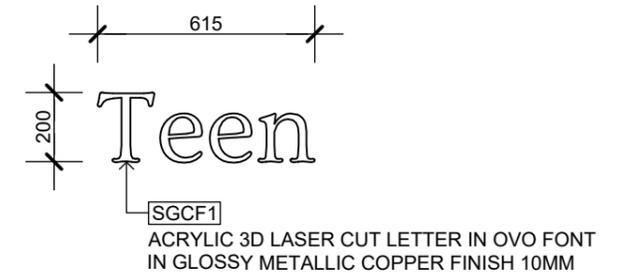

06 TEEN SIGNAGE DETAIL  
A22 1:20



STUDIO GAIA  
1234 5678  
interiors@studiogaia.com.au  
www.studiogaia.com.au

NOTES:

CLIENT:

LUCY MAJOR  
lucymajor@gmail.com  
0412 345 678

STAGE:

FOR TENDER

DATE:15-08-2024

TITLE:

SIGNAGE DETAILS - SHEET ONE

SCALE: 1:20

PROJECT:

KARIJINI SKINCARE RETAIL FIT OUT  
1-1253 ZONE 12, GROUND LEVEL  
WESTFIELD CAROUSEL, CANNINGTON WA 6107


DRAWN BY:

STUDIO GAIA


REVISION:

NONE


A22

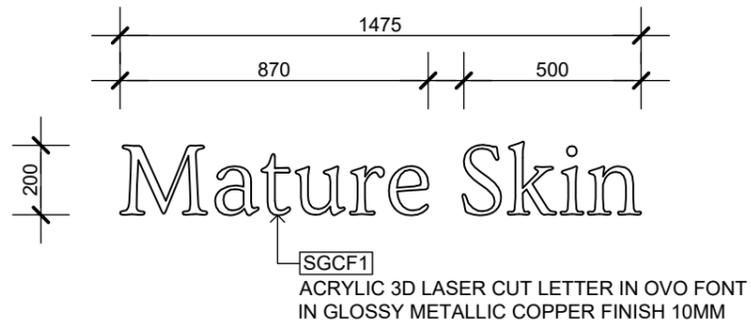


01 MATURE SKIN SIGNAGE DETAIL  
A23 1:20

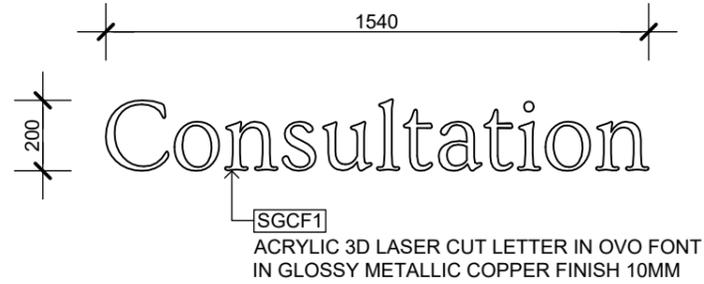


03 CONSULTATION SIGNAGE DETAIL  
A23 1:20

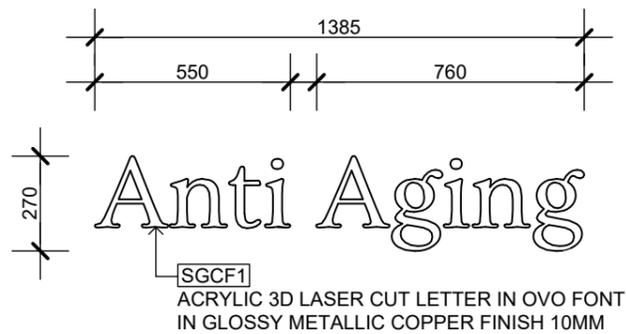

02 ANTI AGING SIGNAGE DETAIL  
A23 1:20

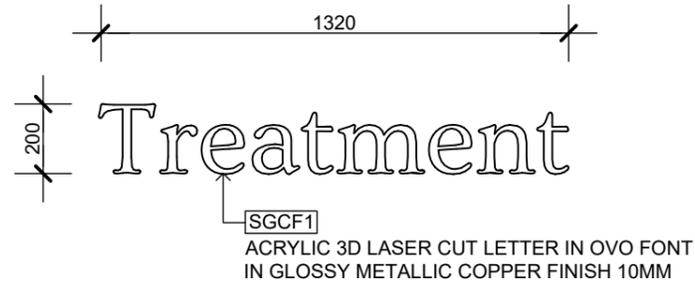

04 TREATMENT SIGNAGE DETAIL  
A23 1:20

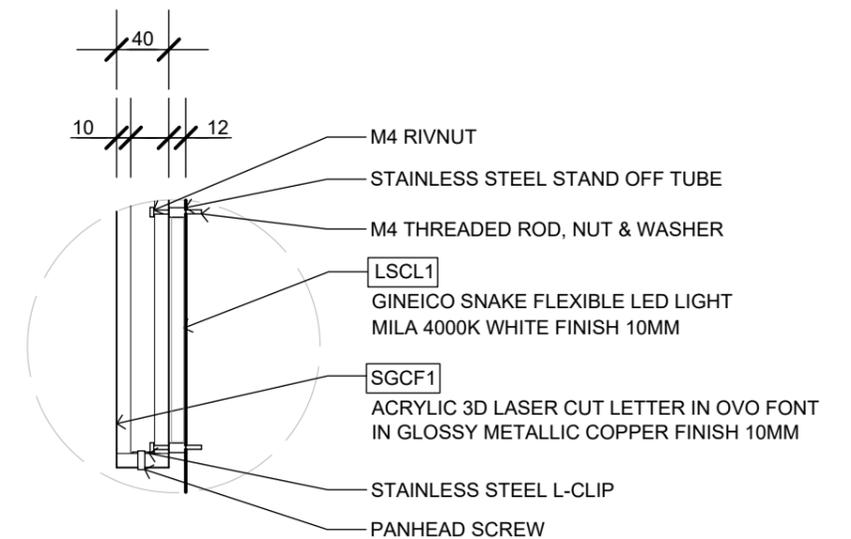

05 SIGNAGE FIXING DETAILS  
A23 1:5



STUDIO GAIA  
1234 5678  
interiors@studiogaia.com.au  
www.studiogaia.com.au

NOTES:

CLIENT:

LUCY MAJOR  
lucymajor@email.com  
0412 345 678

STAGE:

FOR TENDER

DATE:15-08-2024

TITLE:

SIGNAGE DETAILS - SHEET TWO

VARIOUS SCALES

PROJECT:

KARLUNI SKINCARE RETAIL FIT OUT  
1-1253 ZONE 12, GROUND LEVEL  
WESTFIELD CAROUSEL, CANNINGTON WA 6107

DRAWN BY:

STUDIO GAIA

REVISION:

NONE

**A23**